



GENERAL NOTES	
1.	ALL ELEVATIONS ARE MEASURED FROM LEVEL B4 I.e. 1029'-0".
2.	ALL DIMENSIONS & ELEVATIONS ARE IN FEET AND INCHES.
3.	COORDINATION PROCESS IS STILL UNDER PROGRESS. PLEASE DO NOT CONSIDER THIS DRAWING AS FINAL ONE.

ABBREVIATION	
SD	STORM DRAIN
I.E.	INVERT ELEVATION
SAN	SANITARY
V	VENT
PD	PUMP DISCHARGE
GW	GREASE WASTE
FIA	FROM ABOVE
T/B	TO BELOW
F/B	FROM BELOW
FCO	FLOOR CLEANOUT
GCO	GRADE CLEANOUT
ESP-1,2,3	ELEVATOR SUMP PUMP
TD-1	TRENCH DRAIN
FD-1	FLOOR DRAIN
CO	CLEAN OUT
PD-1	PARKING DRAIN
HD	HUB DRAIN
AAV	AIR ADMITTANCE VALVE

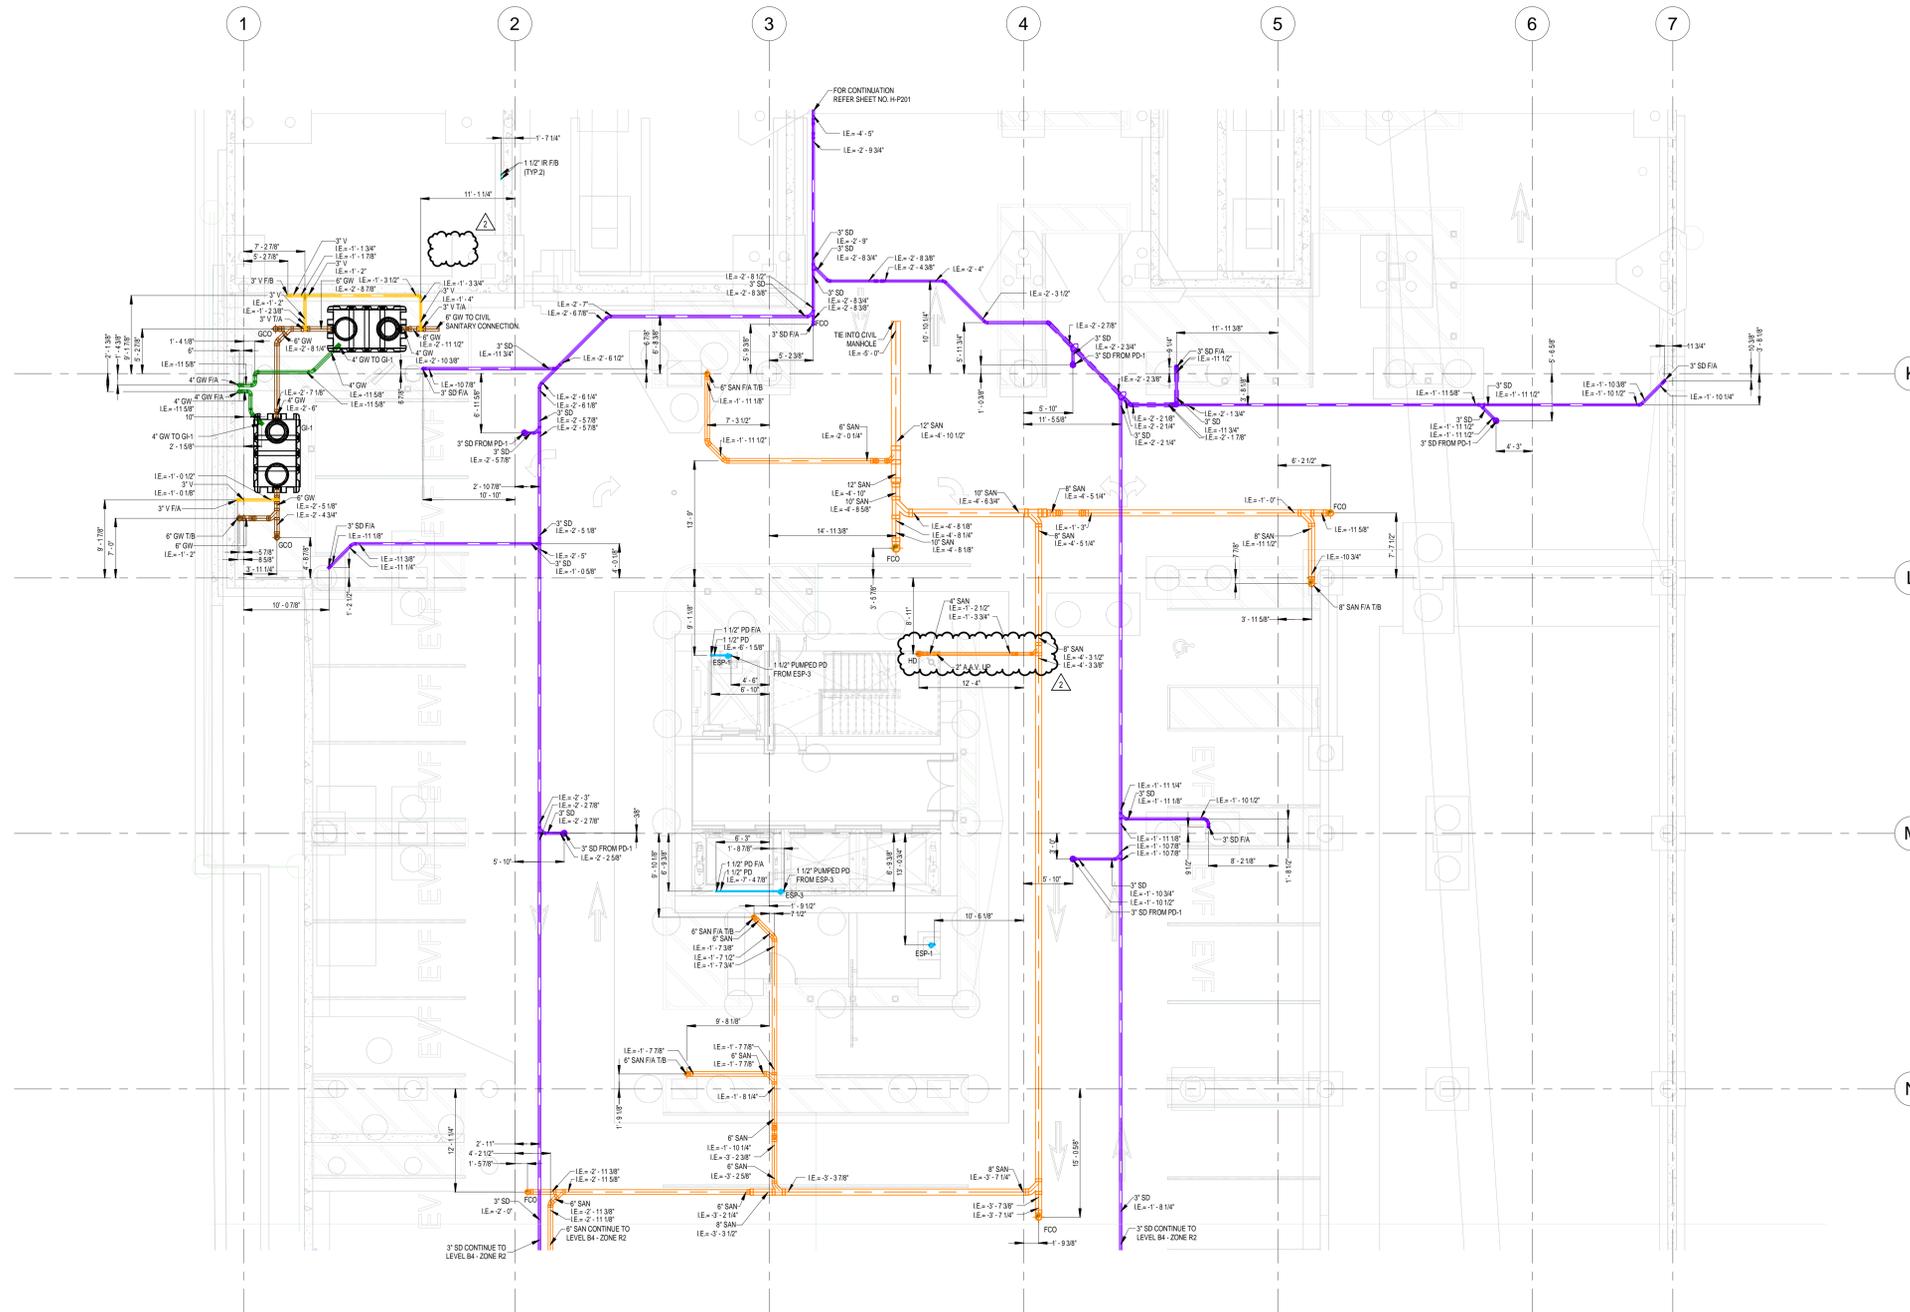

1 PLUMBING FLOOR PLAN - LEVEL UG - ZONE R1
R-P200 1/8" = 1'-0"

REV.	DATE	DESCRIPTION
2	11.09.2023	ISSUED FOR REVIEW
1	10.09.2023	ISSUED FOR REVIEW
0	09.01.2023	ISSUED FOR REVIEW

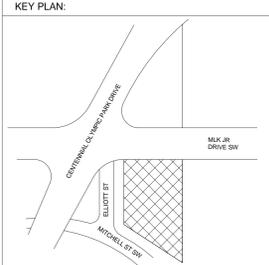

PROJECT NAME:
CENTENNIAL YARDS - HOTEL (H/E1) & RESIDENTIAL (R/E2)

AREA:
PLUMBING FLOOR PLAN - LEVEL UG - ZONE R1

SCALE	DATE
AS MENTIONED	11.09.2023


DRAWING NUMBER:
R-P200

GENERAL NOTES

- ALL ELEVATIONS ARE MEASURED FROM LEVEL B4 I.E. 1029'-0".
- ALL DIMENSIONS & ELEVATIONS ARE IN FEET AND INCHES.
- COORDINATION PROCESS IS STILL UNDER PROGRESS. PLEASE DO NOT CONSIDER THIS DRAWING AS FINAL ONE.

ABBREVIATION


SD	STORM DRAIN
I.E.	INVERT ELEVATION
SAN	SANITARY
V	VENT
PD	PUMP DISCHARGE
GW	GREASE WASTE
F/A	FROM ABOVE
T/B	TO BELOW
F/B	FROM BELOW
FCO	FLOOR CLEANOUT
GOO	GRADE CLEANOUT
ESP-1,2,3	ELEVATOR SUMP PUMP
TD-1	TRENCH DRAIN
FD-1	FLOOR DRAIN
CO	CLEAN OUT
PD-1	PARKING DRAIN
HD	HUB DRAIN
AAV	AIR ADMITTANCE VALVE

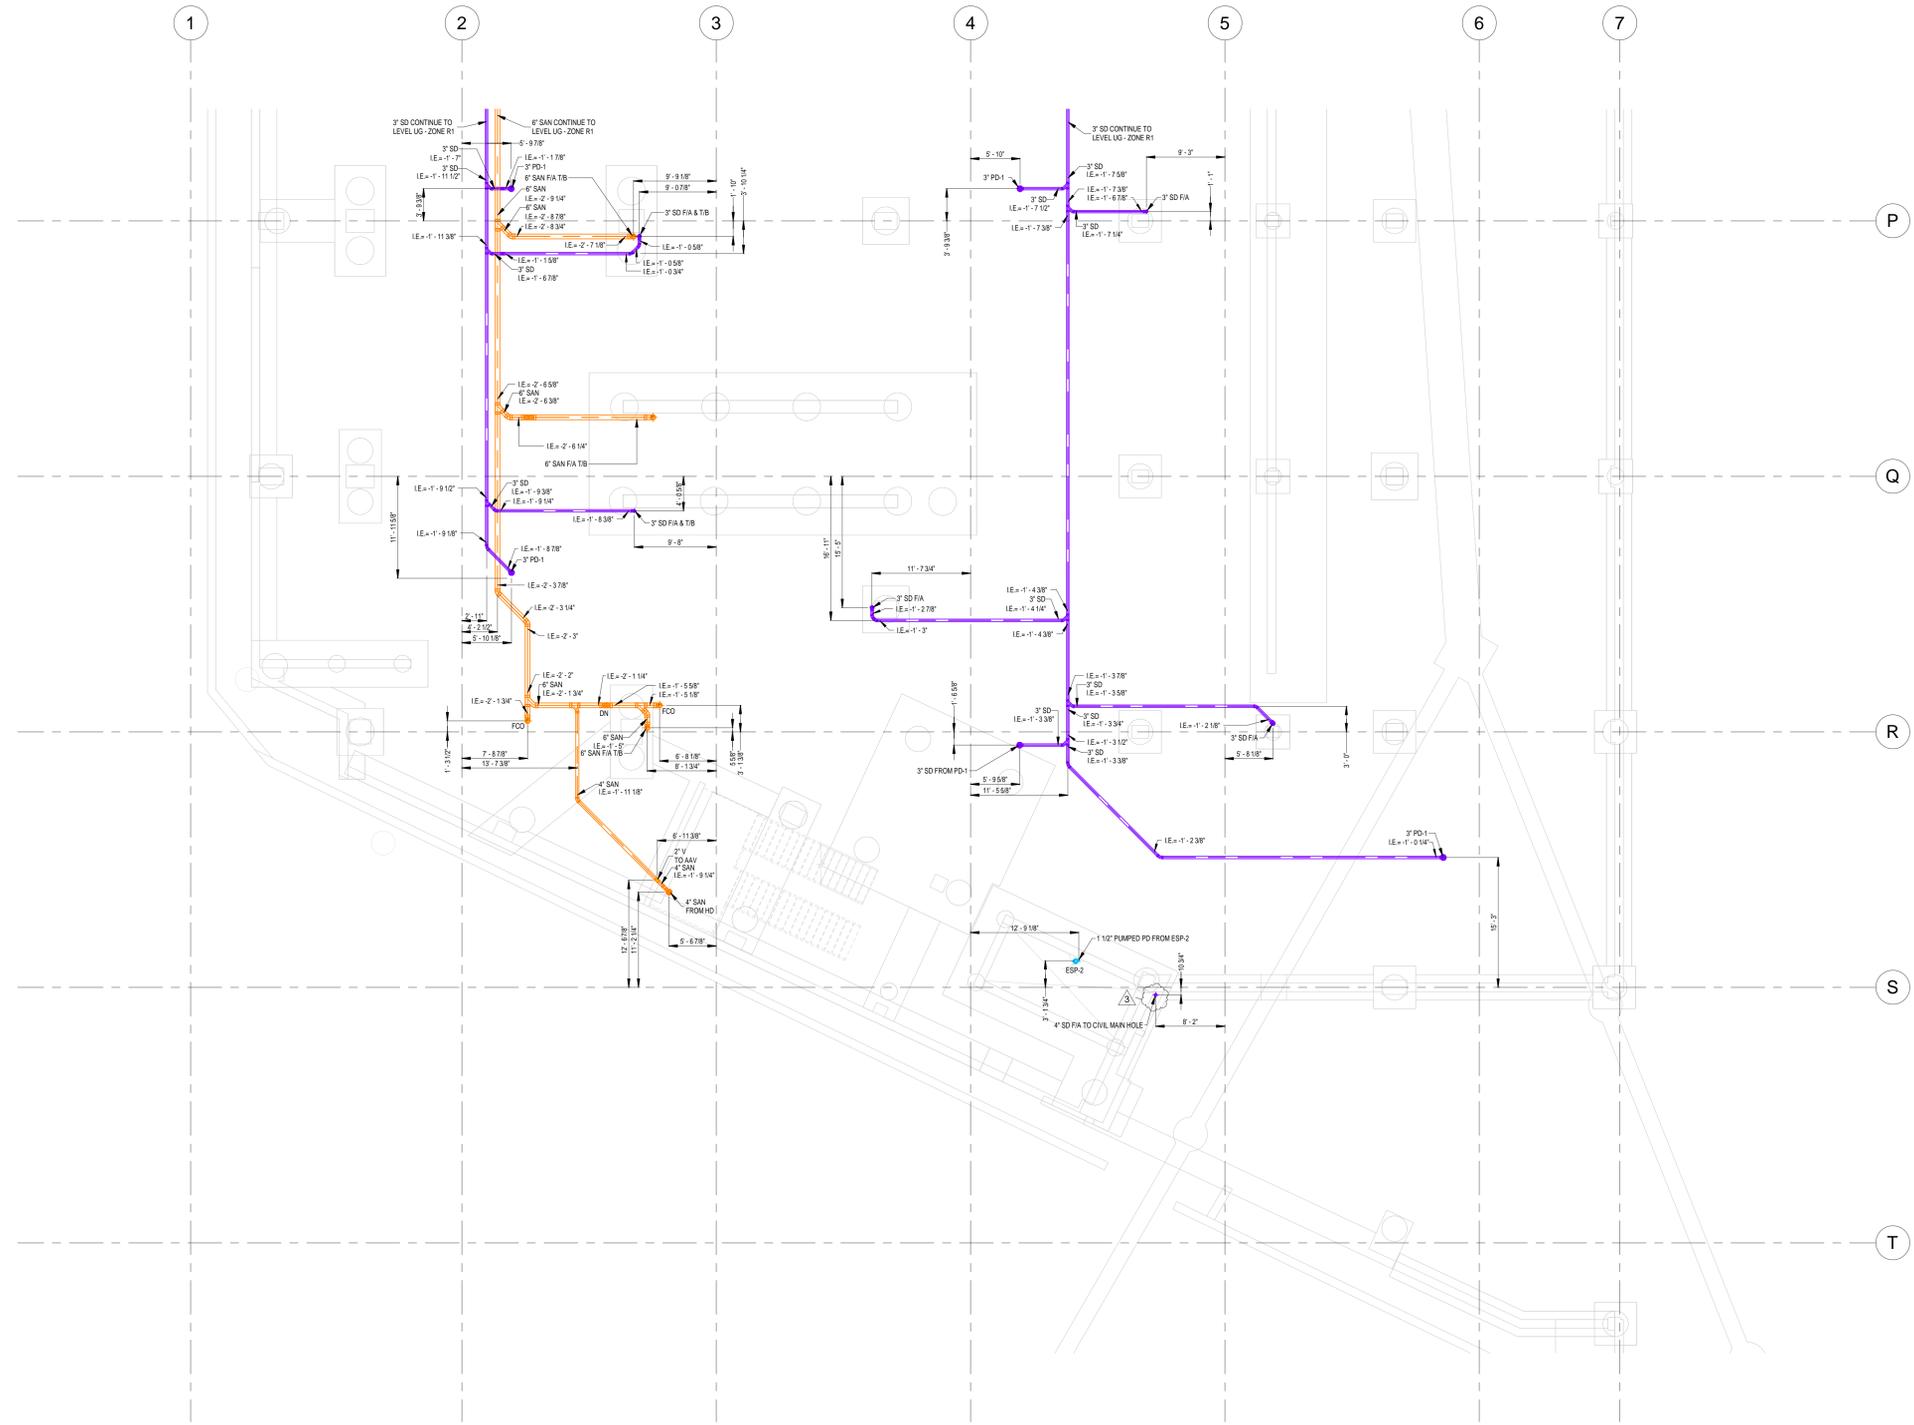

1 PLUMBING FLOOR PLAN - LEVEL UG - ZONE R2
R-P201 1/8" = 1'-0"

REV. **DATE** **DESCRIPTION**

3	09-02-2024	ISSUED FOR REVIEW
2	11-09-2023	ISSUED FOR REVIEW
1	10-09-2023	ISSUED FOR REVIEW
0	09-01-2023	ISSUED FOR REVIEW

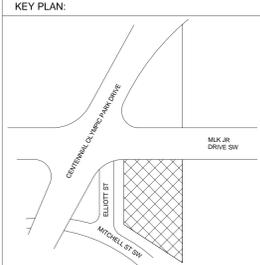

PROJECT NAME:
CENTENNIAL YARDS - HOTEL (H/E1) & RESIDENTIAL (R/E2)

AREA:
PLUMBING FLOOR PLAN - LEVEL UG - ZONE R2

SCALE	DATE
AS MENTIONED	09-02-2024


DRAWING NUMBER:
R-P201

GENERAL NOTES

1. ALL ELEVATIONS ARE MEASURED FROM LEVEL B3 I.e. 1039'-0".
2. ALL DIMENSIONS & ELEVATIONS ARE IN FEET AND INCHES.
3. COORDINATION PROCESS IS STILL UNDER PROGRESS. PLEASE DO NOT CONSIDER THIS DRAWING AS FINAL ONE.

ABBREVIATION


SD	STORM DRAIN
I.E.	INVERT ELEVATION
SAN	SANITARY
V	VENT
PD	PUMP DISCHARGE
GW	GREASE WASTE
F/A	FROM ABOVE
T/B	TO BELOW
F/B	FROM BELOW
FCO	FLOOR CLEANOUT
GCO	GRADE CLEANOUT
ESP-1,2,3	ELEVATOR SUMP PUMP
TD-1	TRENCH DRAIN
FD-1	FLOOR DRAIN
CO	CLEAN OUT
PD-1	PUMPING DRAIN
HD	HUB DRAIN
AAV	AIR ADMITTANCE VALVE

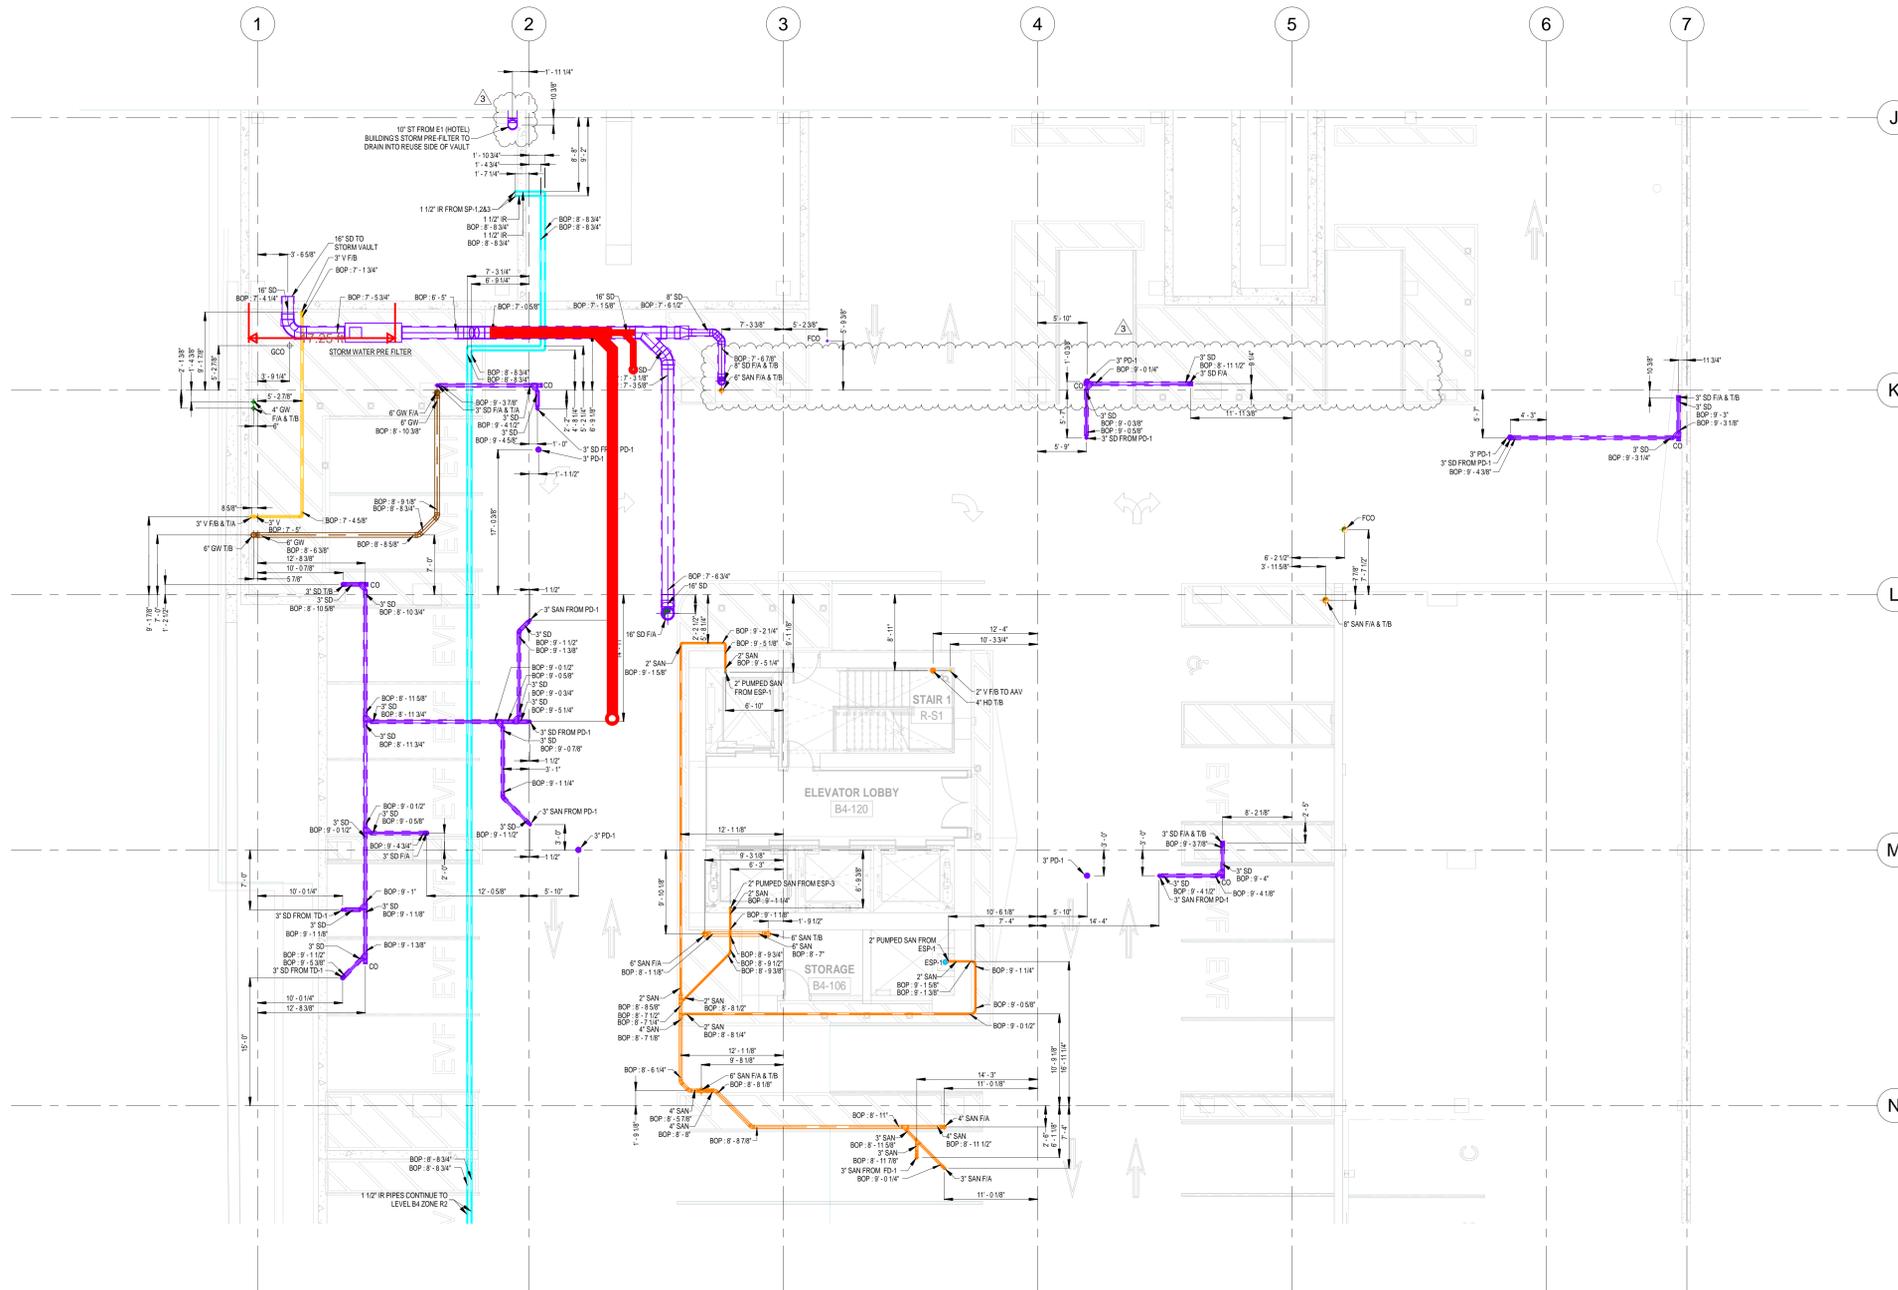

1 PLUMBING FLOOR PLAN - LEVEL B4 - ZONE R1
R-P202 1/8" = 1'-0"

REV. **DATE** **DESCRIPTION**

3	09-02-2024	ISSUED FOR REVIEW
2	11-09-2023	ISSUED FOR REVIEW
1	10-19-2023	ISSUED FOR REVIEW
0	10-06-2023	ISSUED FOR REVIEW

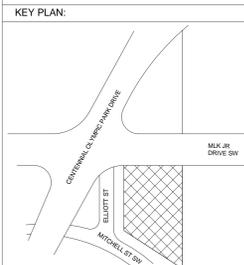

PROJECT NAME:
CENTENNIAL YARDS - HOTEL (H/E1) & RESIDENTIAL (R/E2)

AREA:
PLUMBING FLOOR PLAN - LEVEL B4 - ZONE R1

SCALE: AS MENTIONED DATE: 09-02-2024


DRAWING NUMBER:
R-P202

GENERAL NOTES

1. ALL ELEVATIONS ARE MEASURED FROM LEVEL B4 I.e. 1029'-0".
2. ALL DIMENSIONS & ELEVATIONS ARE IN FEET AND INCHES.
3. COORDINATION PROCESS IS STILL UNDER PROGRESS. PLEASE DO NOT CONSIDER THIS DRAWING AS FINAL ONE.

ABBREVIATION

SD	STORM DRAIN
I.E.	INVERT ELEVATION
SAN	SANITARY
V	VENT
PD	PUMP DISCHARGE
GW	GREASE WASTE
F/A	FROM ABOVE
T/B	TO BELOW
F/B	FROM BELOW
FCO	FLOOR CLEANOUT
GCO	GRADE CLEANOUT
ESP-1,2,3	ELEVATOR SUMP PUMP
TD-1	TRENCH DRAIN
FD-1	FLOOR DRAIN
CO	CLEAN OUT
PD-1	PARKING DRAIN
HD	HUB DRAIN
AAV	AIR ADMITTANCE VALVE

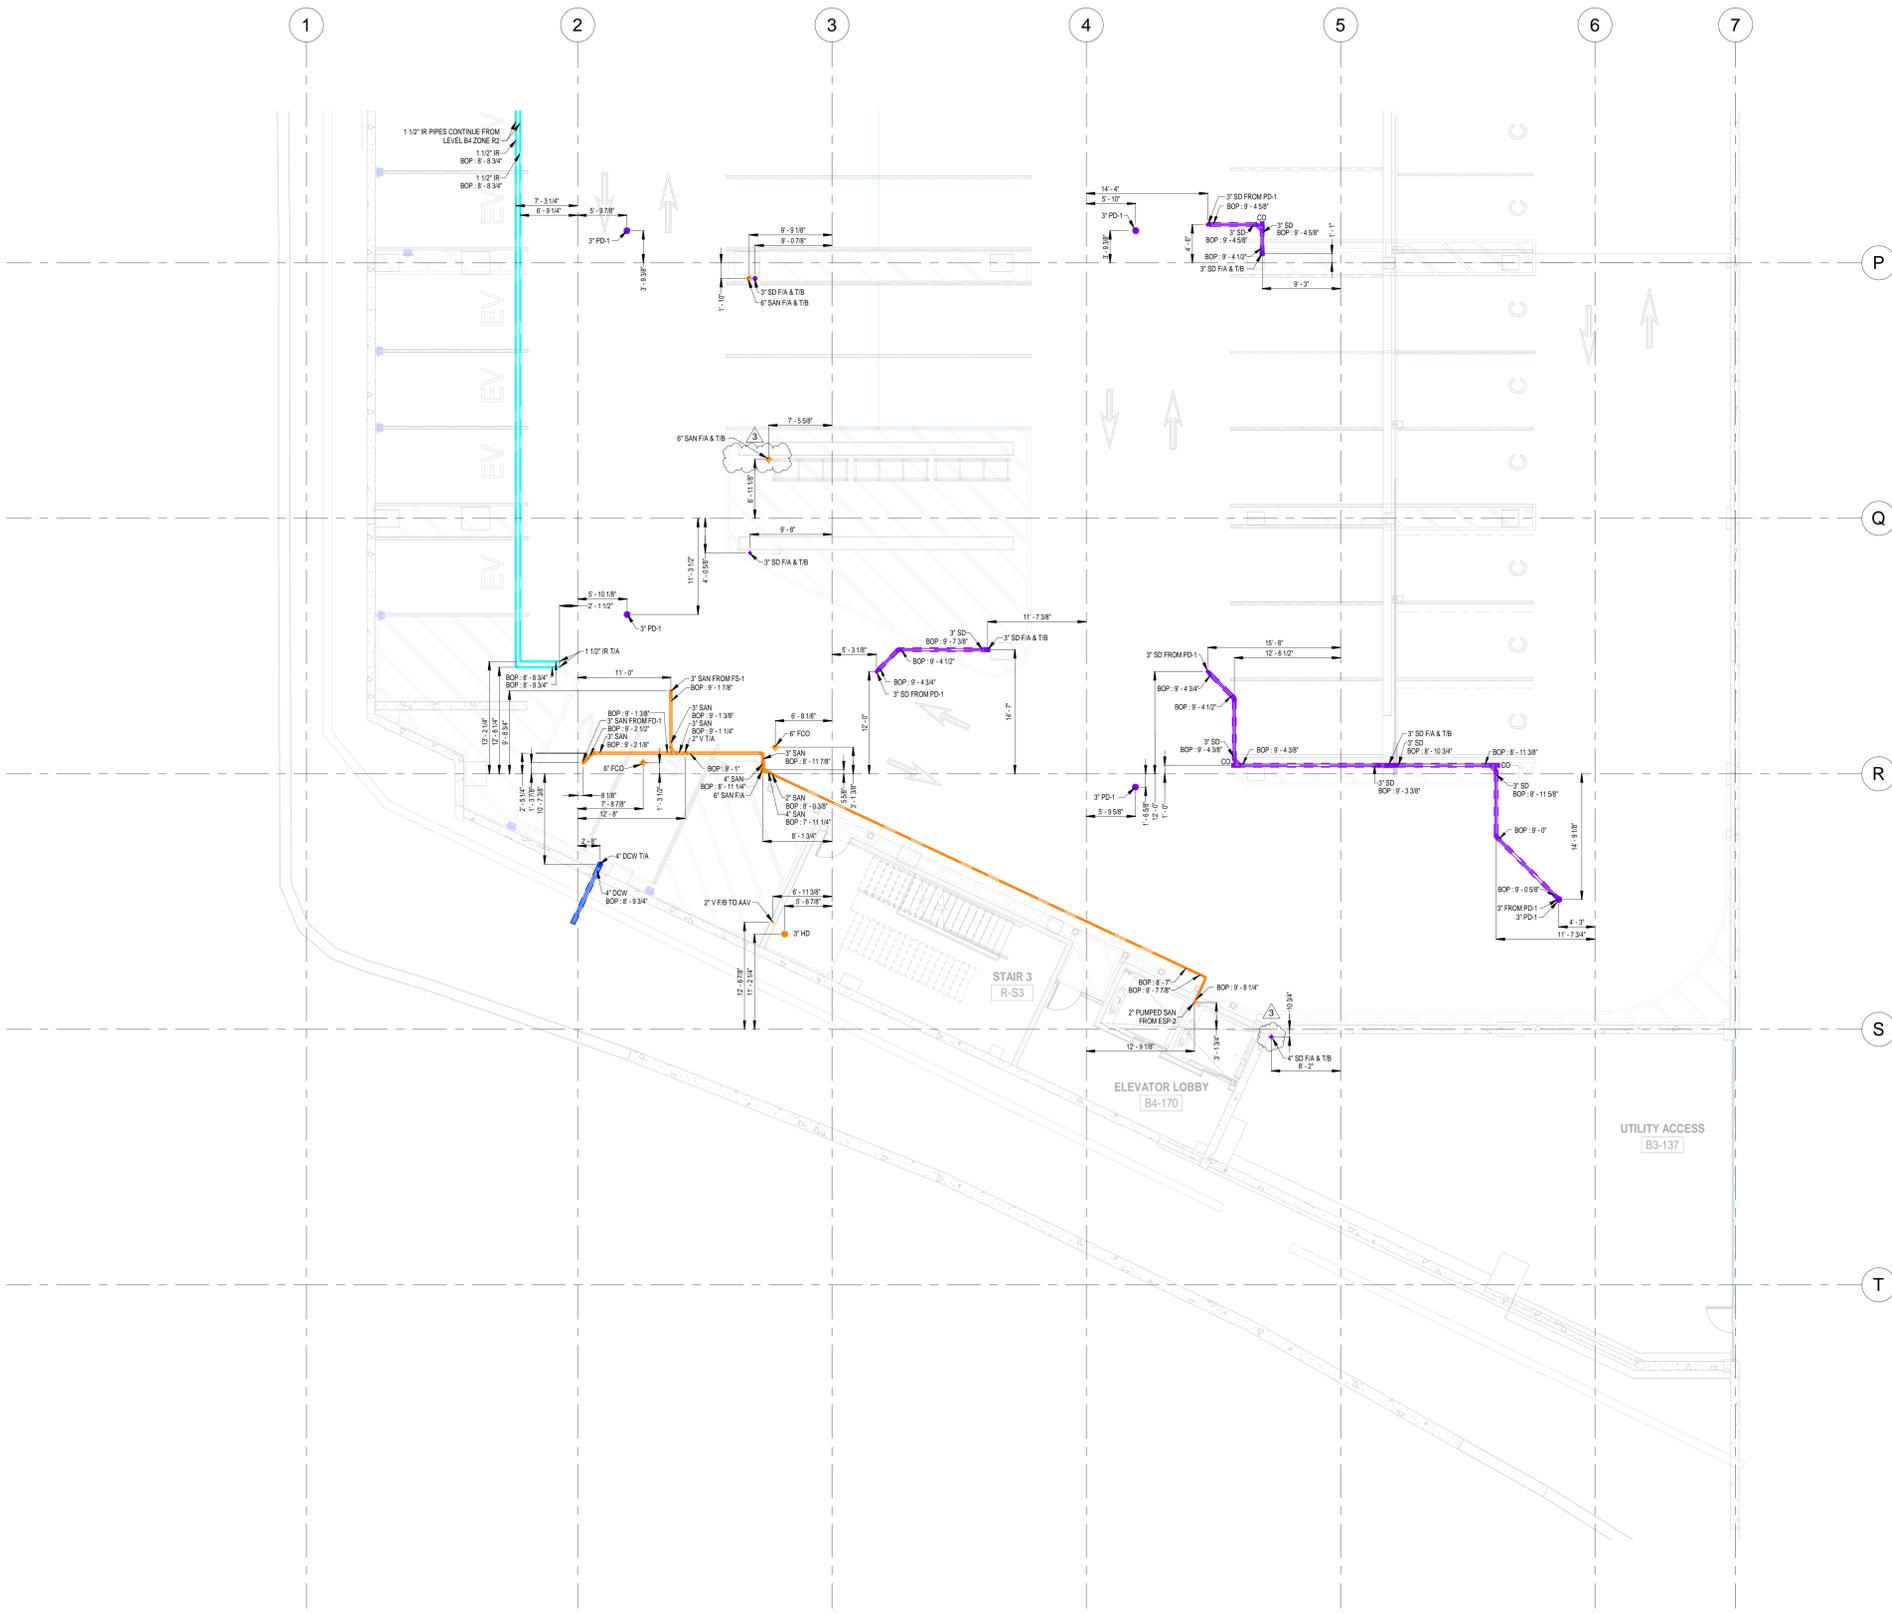

1 PLUMBING FLOOR PLAN - LEVEL B4 - ZONE R2
R-P203 1/8" = 1'-0"

REV. DATE DESCRIPTION

3	09-02-2024	ISSUED FOR REVIEW
2	11-09-2023	ISSUED FOR REVIEW
1	10-19-2023	ISSUED FOR REVIEW
0	10-06-2023	ISSUED FOR REVIEW



PROJECT NAME:
CENTENNIAL YARDS - HOTEL (H/E1) & RESIDENTIAL (R/E2)


AREA:
PLUMBING FLOOR PLAN - LEVEL B4 - ZONE R2

SCALE	DATE
AS MENTIONED	09-02-2024

DRAWING NUMBER:
R-P203


GENERAL NOTES	
1.	ALL ELEVATIONS ARE MEASURED FROM LEVEL B3 @ 1039'-0".
2.	ALL DIMENSIONS & ELEVATIONS ARE IN FEET AND INCHES.
3.	COORDINATION PROCESS IS STILL UNDER PROGRESS. PLEASE DO NOT CONSIDER THIS DRAWING AS FINAL ONE.

ABBREVIATION	
SD	STORM DRAIN
IE	INVERT ELEVATION
SAN	SANITARY
V	VENT
PD	PUMP DISCHARGE
GW	GREASE WASTE
F/A	FROM ABOVE
T/B	TO BELOW
F/B	FROM BELOW
FCO	FLOOR CLEANOUT
GCO	GRADE CLEANOUT
ESP-1,2,3	ELEVATOR SUMP PUMP
TD-1	TRENCH DRAIN
FD-1	FLOOR DRAIN
CO	CLEAN OUT
PD-1	PARKING DRAIN
HD	HUB DRAIN
AAV	AIR ADMITTANCE VALVE

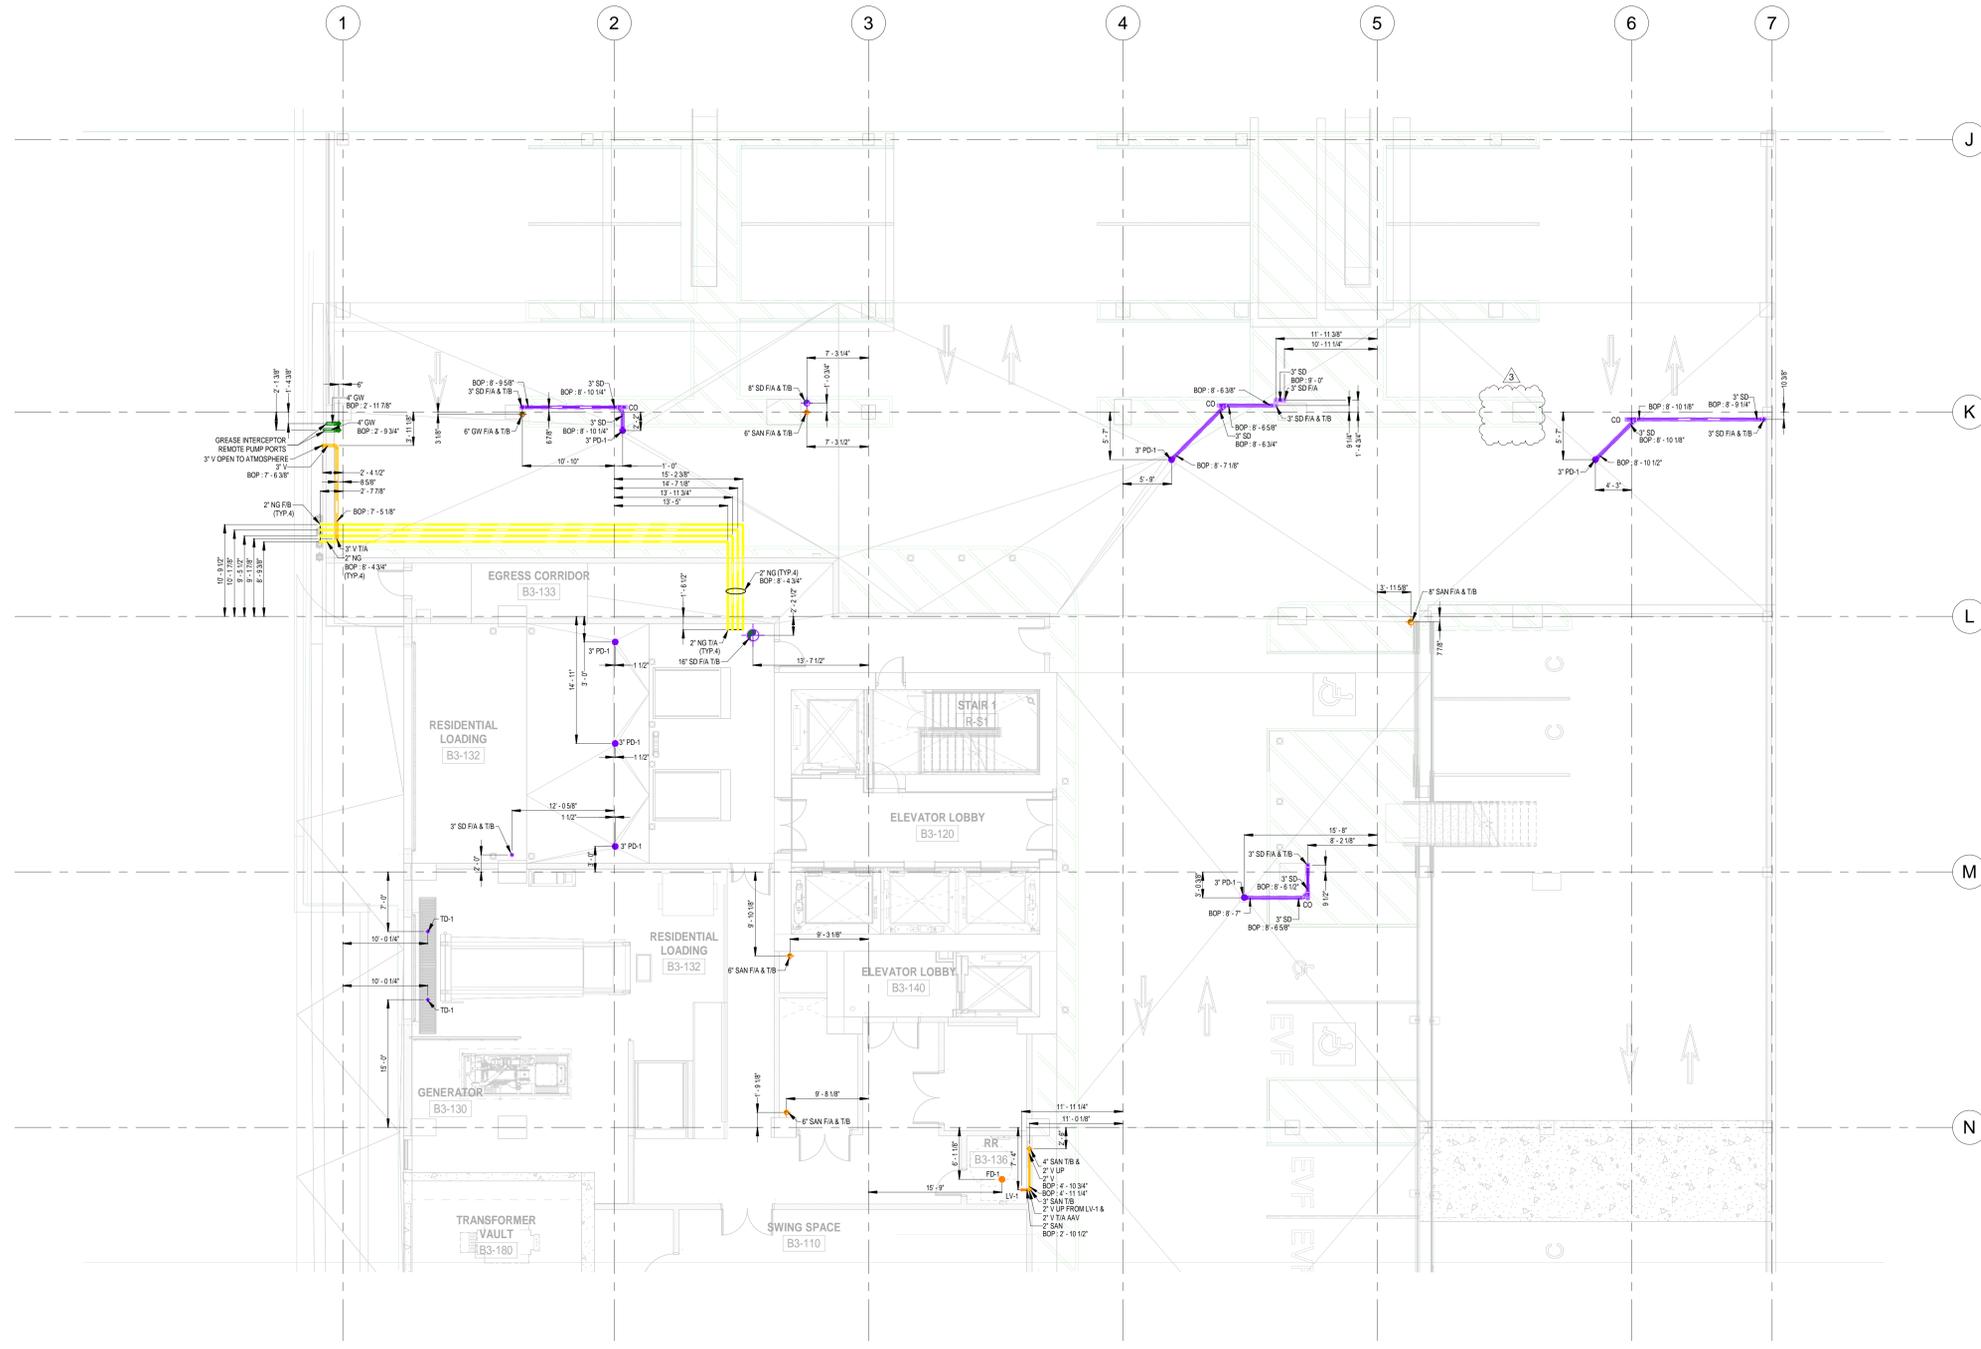

1 PLUMBING FLOOR PLAN - LEVEL B3 - ZONE R1
R-P204 1/8" = 1'-0"

REV.	DATE	DESCRIPTION
3	09-02-2024	ISSUED FOR REVIEW
2	11-09-2023	ISSUED FOR REVIEW
1	10-21-2023	ISSUED FOR REVIEW
0	10-04-2023	ISSUED FOR REVIEW

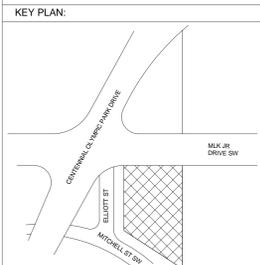

PROJECT NAME:
CENTENNIAL YARDS - HOTEL (H/E1) & RESIDENTIAL (R/E2)

AREA:
PLUMBING FLOOR PLAN - LEVEL B3 - ZONE R1

SCALE	DATE
AS MENTIONED	09-02-2024


DRAWING NUMBER:
R-P204

GENERAL NOTES

1. ALL ELEVATIONS ARE MEASURED FROM LEVEL B3 I.e. -31' 0".
2. ALL DIMENSIONS & ELEVATIONS ARE IN FEET AND INCHES.
3. COORDINATION PROCESS IS STILL UNDER PROGRESS. PLEASE DO NOT CONSIDER THIS DRAWING AS FINAL ONE.

ABBREVIATION

SD	STORM DRAIN
I.E.	INVERT ELEVATION
SAN	SANITARY
V	VENT
PD	PUMP DISCHARGE
GW	GREASE WASTE
F/A	FROM ABOVE
T/B	TO BELOW
FCO	FLOOR CLEANOUT
GCO	GRADE CLEANOUT
ESP-1,2,3	ELEVATOR SUMP PUMP
BOP	BOTTOM OF PIPE
CO	CLEAN OUT
NG	NATURAL GAS
PD-1	PARKING DRAIN
AAV	AIR ADMITTANCE VALVE
HD	HUB DRAIN

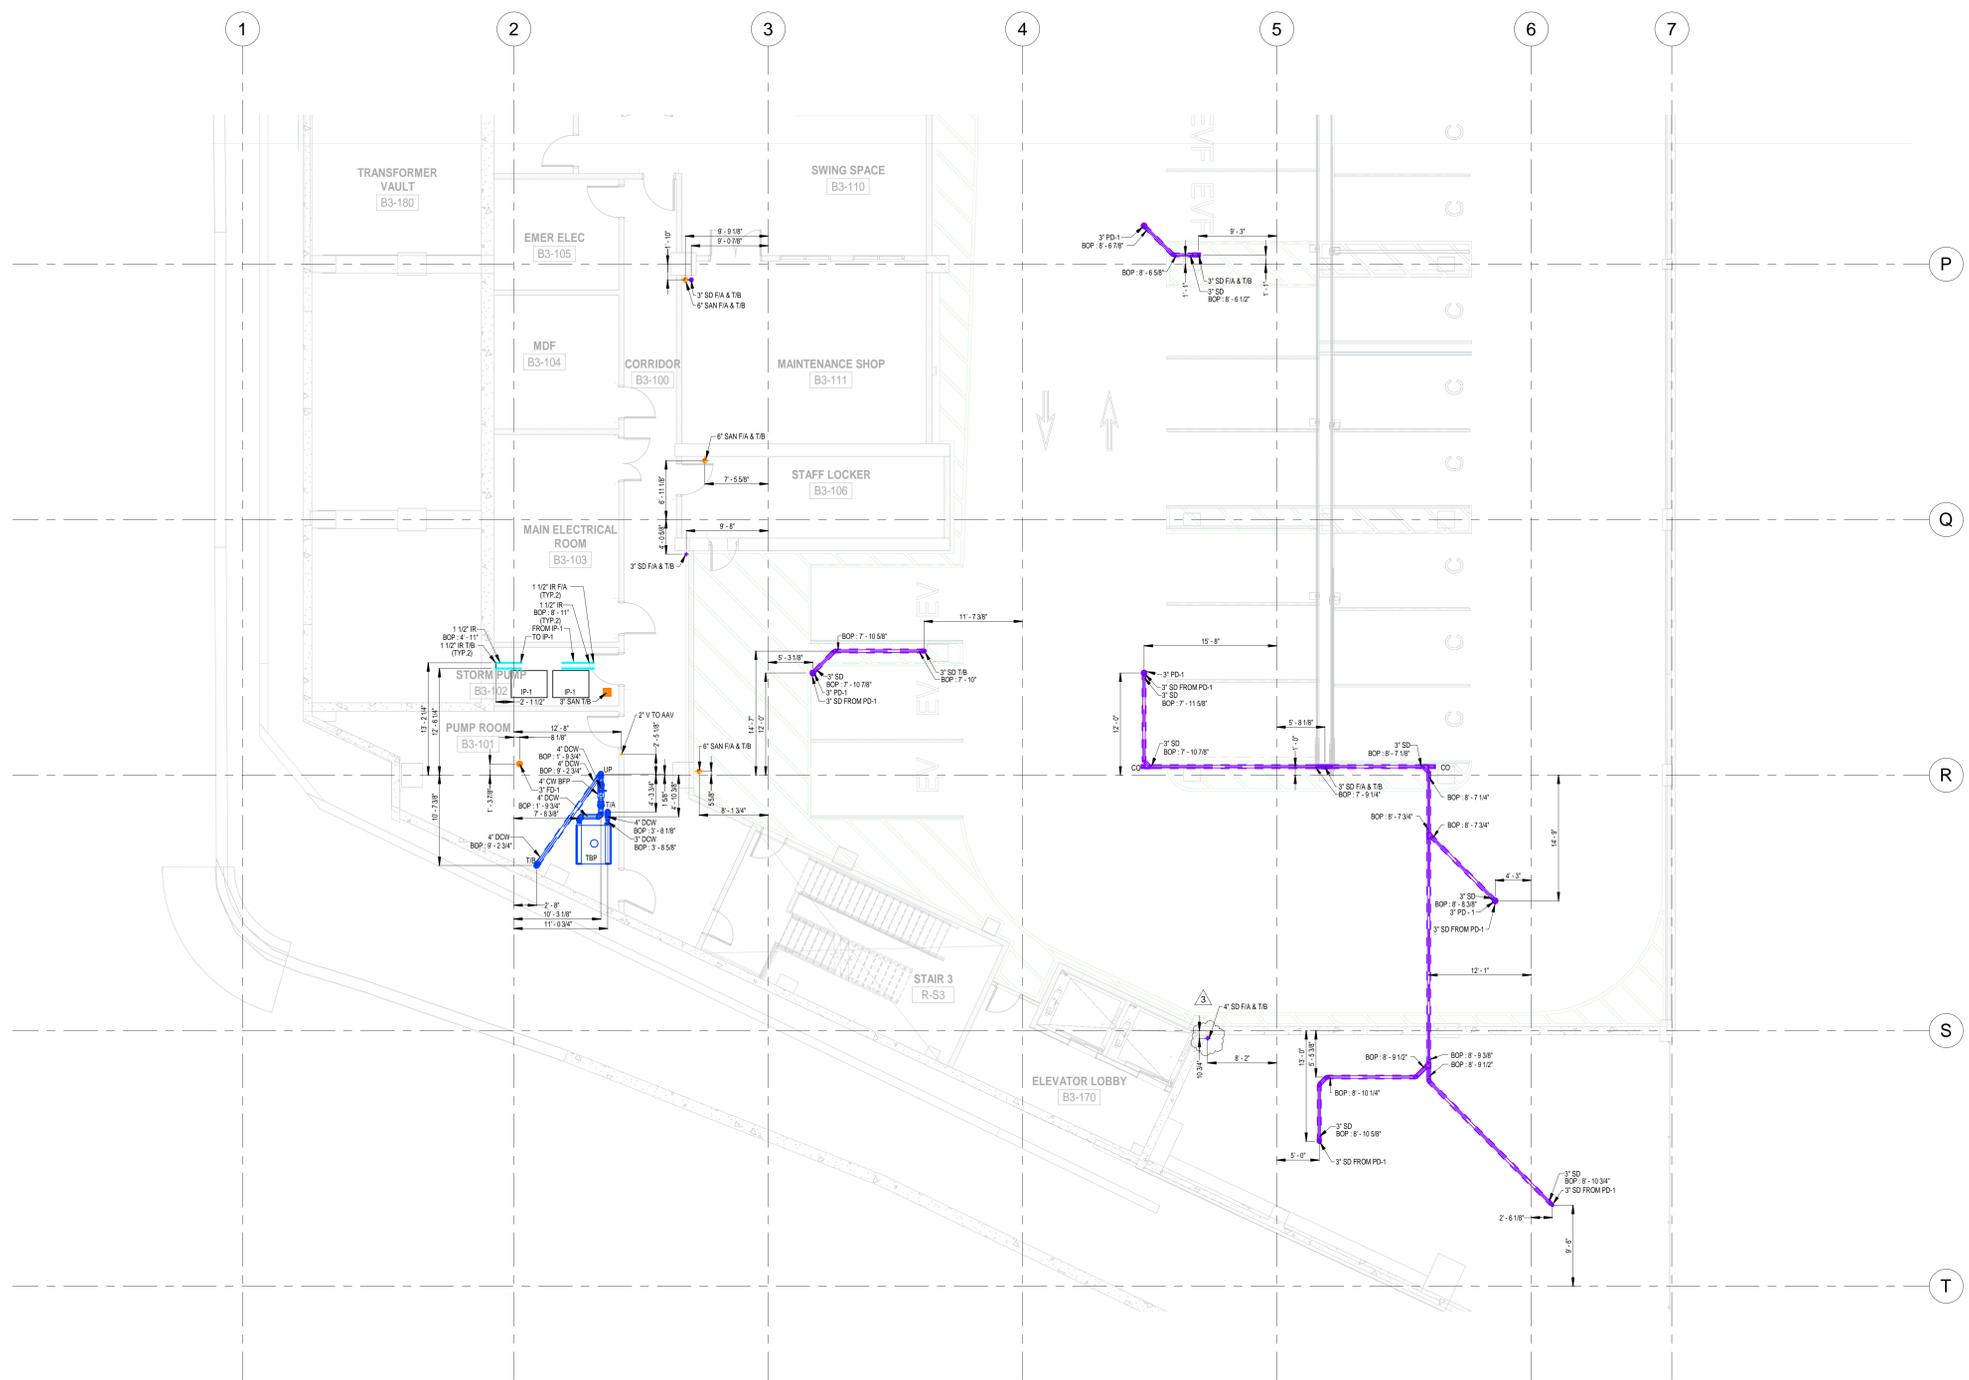

1 PLUMBING FLOOR PLAN - LEVEL B3 - ZONE R2
R-P205 1/8" = 1'-0"

REV.	DATE	DESCRIPTION
3	09-02-2024	ISSUED FOR REVIEW
2	11-09-2023	ISSUED FOR REVIEW
1	10-21-2023	ISSUED FOR REVIEW
0	10-04-2023	ISSUED FOR REVIEW

KEY PLAN:



PROJECT NAME:

CENTENNIAL YARDS - HOTEL (H/E1) & RESIDENTIAL (R/E2)

AREA:

PLUMBING FLOOR PLAN - LEVEL B3 - ZONE R2

SCALE	DATE
AS MENTIONED	09-02-2024

DRAWING NUMBER:


R-P205

GENERAL NOTES

- ALL ELEVATIONS ARE MEASURED FROM LEVEL B2 i.e. 1049'-0".
- ALL DIMENSIONS & ELEVATIONS ARE IN FEET AND INCHES.
- COORDINATION PROCESS IS STILL UNDER PROGRESS. PLEASE DO NOT CONSIDER THIS DRAWING AS FINAL ONE.

ABBREVIATION

SD	STORM DRAIN
I.E.	INVERT ELEVATION
SAN	SANITARY
V	VENT
PD	PUMP DISCHARGE
GW	GREASE WASTE
F/A	FROM ABOVE
T/B	TO BELOW
FCO	FLOOR CLEANOUT
GCO	GRADE CLEANOUT
ESP-1,2,3	ELEVATOR SUMP PUMP
BOP	BOTTOM OF PIPE
CO	CLEAN OUT
NG	NATURAL GAS
PD-1	PARKING DRAIN
AAV	AIR ADMITTANCE VALVE
HD	HUB DRAIN

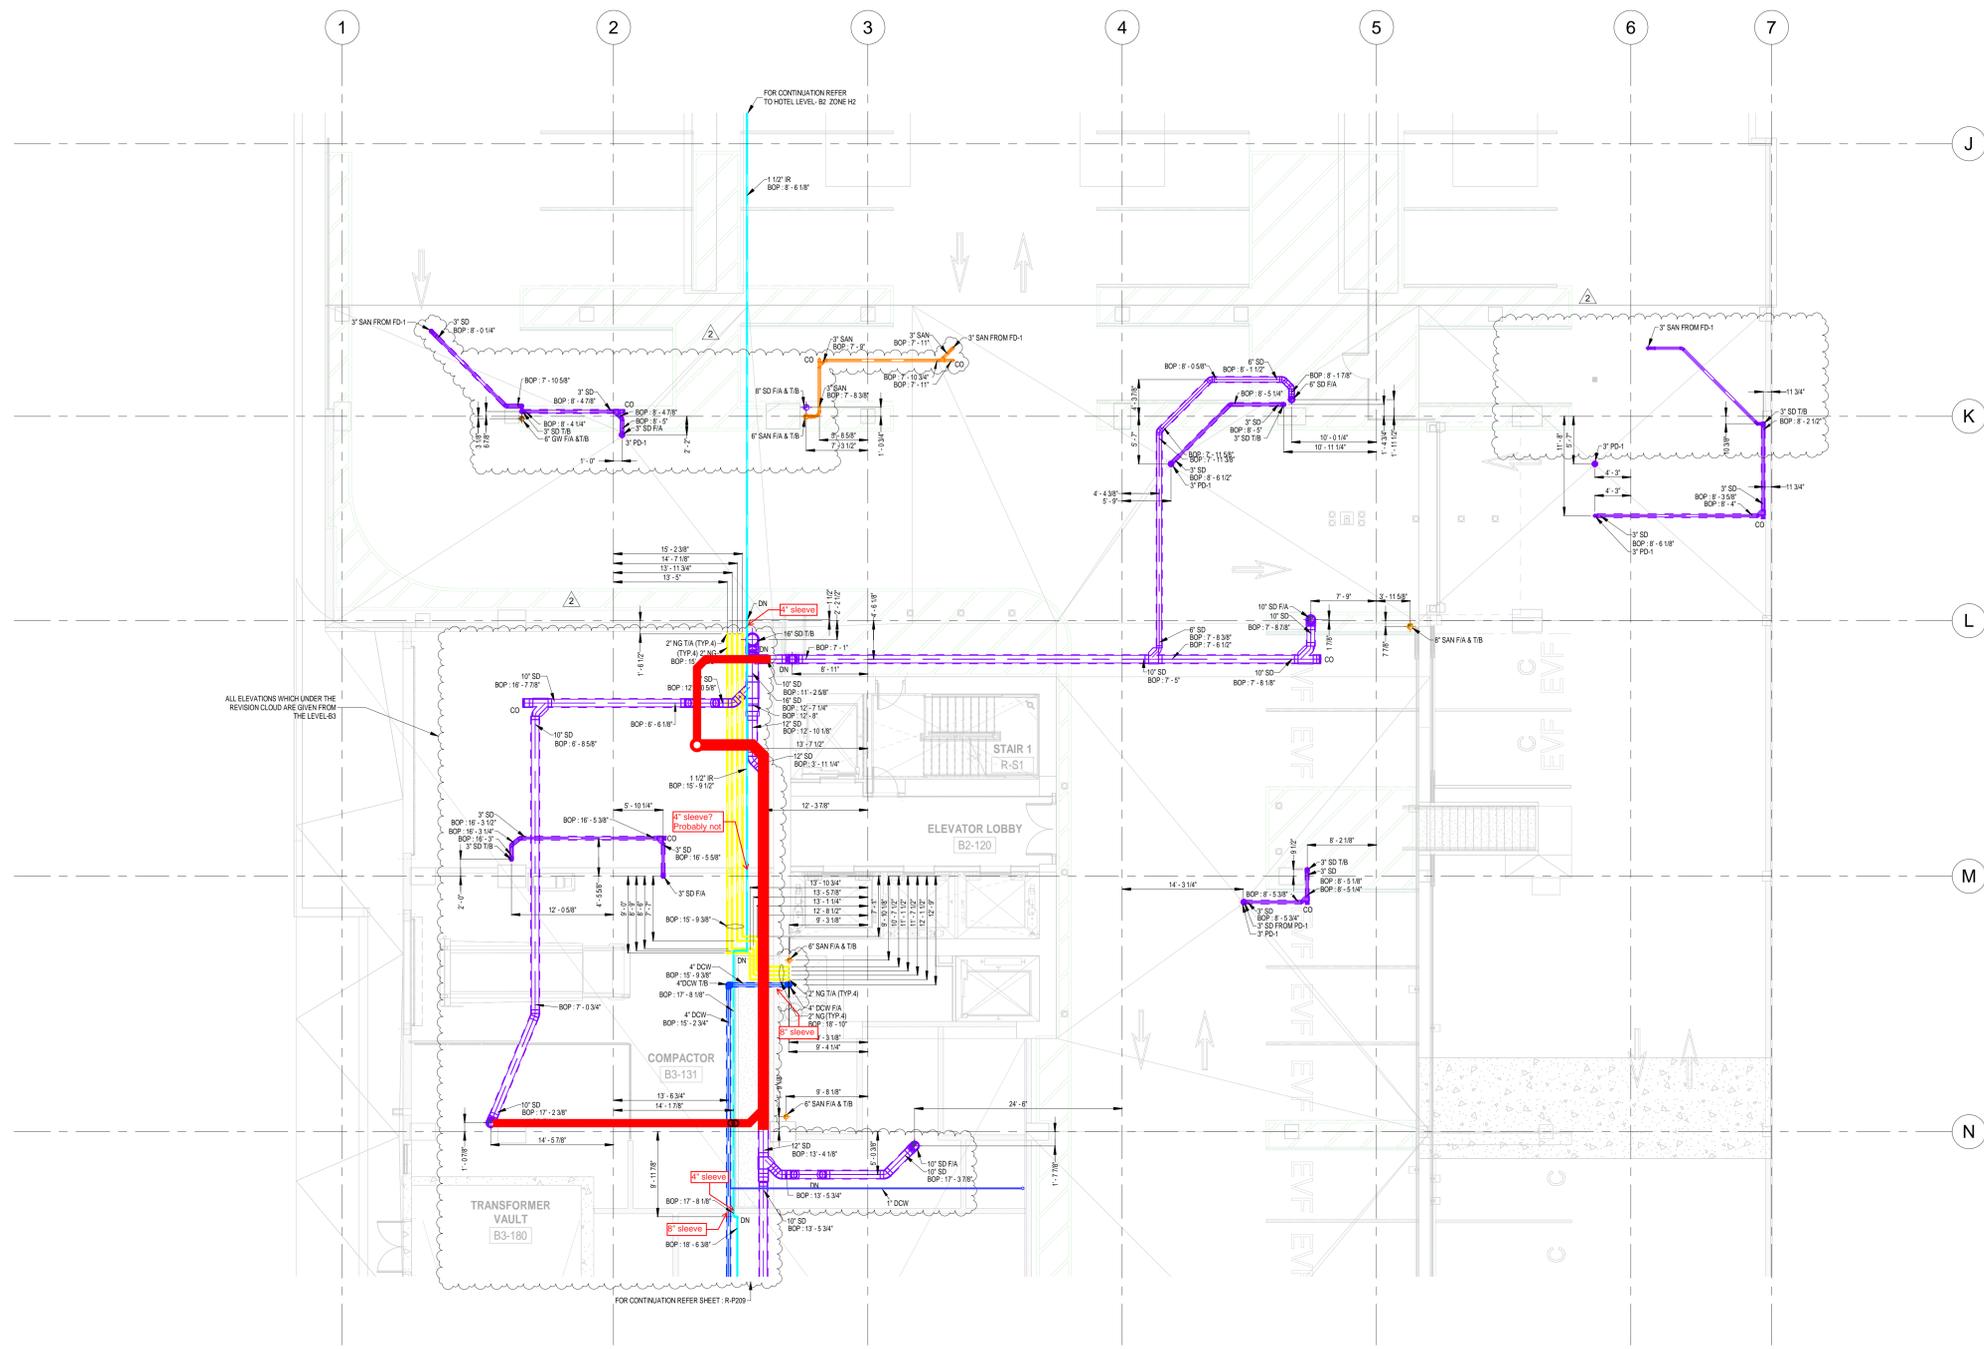


ALL ELEVATIONS WHICH UNDER THE REVISION CLOUD ARE GIVEN FROM THE LEVEL B2

1 PLUMBING FLOOR PLAN - LEVEL B2 - ZONE R1
1/8" = 1'-0"

REV. DATE DESCRIPTION

2	09-02-2024	ISSUED FOR REVIEW
1	11-16-2023	ISSUED FOR REVIEW
0	10-25-2023	ISSUED FOR REVIEW

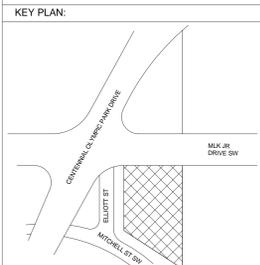

PROJECT NAME:
CENTENNIAL YARDS - HOTEL (H/E1) & RESIDENTIAL (R/E2)

AREA:
PLUMBING FLOOR PLAN - LEVEL B2 - ZONE R1

SCALE	DATE
AS MENTIONED	09-02-2024

DRAWING NUMBER:
R-P208

GENERAL NOTES


- ALL ELEVATIONS ARE MEASURED FROM LEVEL B2 I.e. 1049'-0".
- ALL DIMENSIONS & ELEVATIONS ARE IN FEET AND INCHES.
- COORDINATION PROCESS IS STILL UNDER PROGRESS. PLEASE DO NOT CONSIDER THIS DRAWING AS FINAL ONE.

ABBREVIATION

SD	STORM DRAIN
I.E.	INVERT ELEVATION
SAN	SANITARY
V	VENT
PD	PUMP DRAIN
GW	GREASE WASTE
F/A	FROM ABOVE
T/B	TO BELOW
FCO	FLOOR CLEANOUT
GCO	GRADE CLEANOUT
ESP-1,2,3	ELEVATOR SUMP PUMP
BOP	BOTTOM OF PIPE
CO	CLEAN OUT

REV. **DATE** **DESCRIPTION**

2	09-02-2024	ISSUED FOR REVIEW
1	11-16-2023	ISSUED FOR REVIEW
0	10-25-2023	ISSUED FOR REVIEW

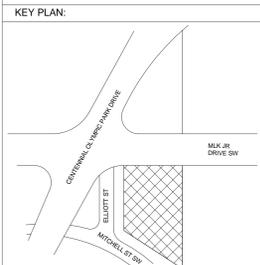


PROJECT NAME:
CENTENNIAL YARDS - HOTEL (H/E1) & RESIDENTIAL (R/E2)


AREA:
PLUMBING FLOOR PLAN - LEVEL B2 - ZONE R2

SCALE	DATE
AS MENTIONED	09-02-2024

DRAWING NUMBER:
R-P209

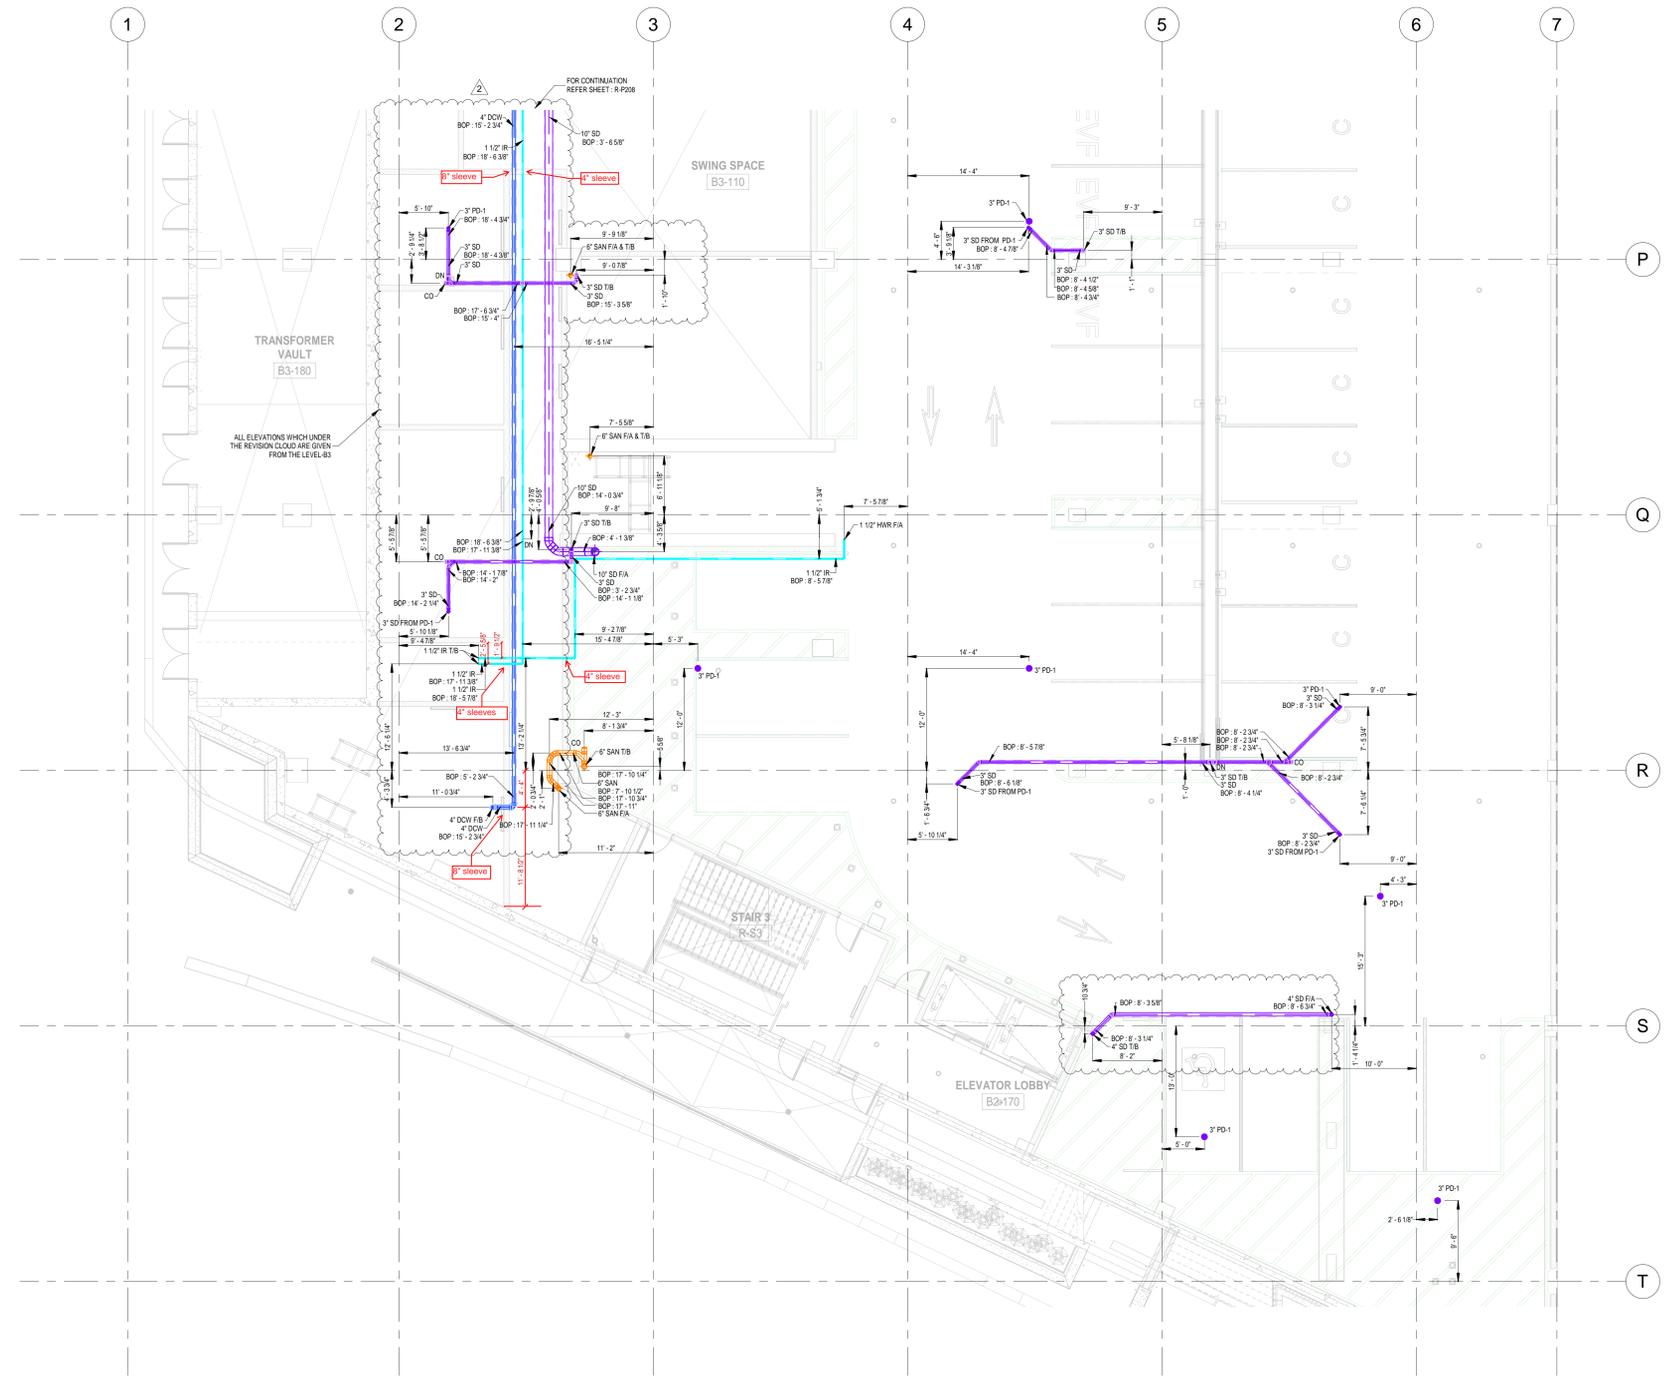

1 PLUMBING FLOOR PLAN - LEVEL B2 - ZONE R2
R-P209 1/8" = 1'-0"

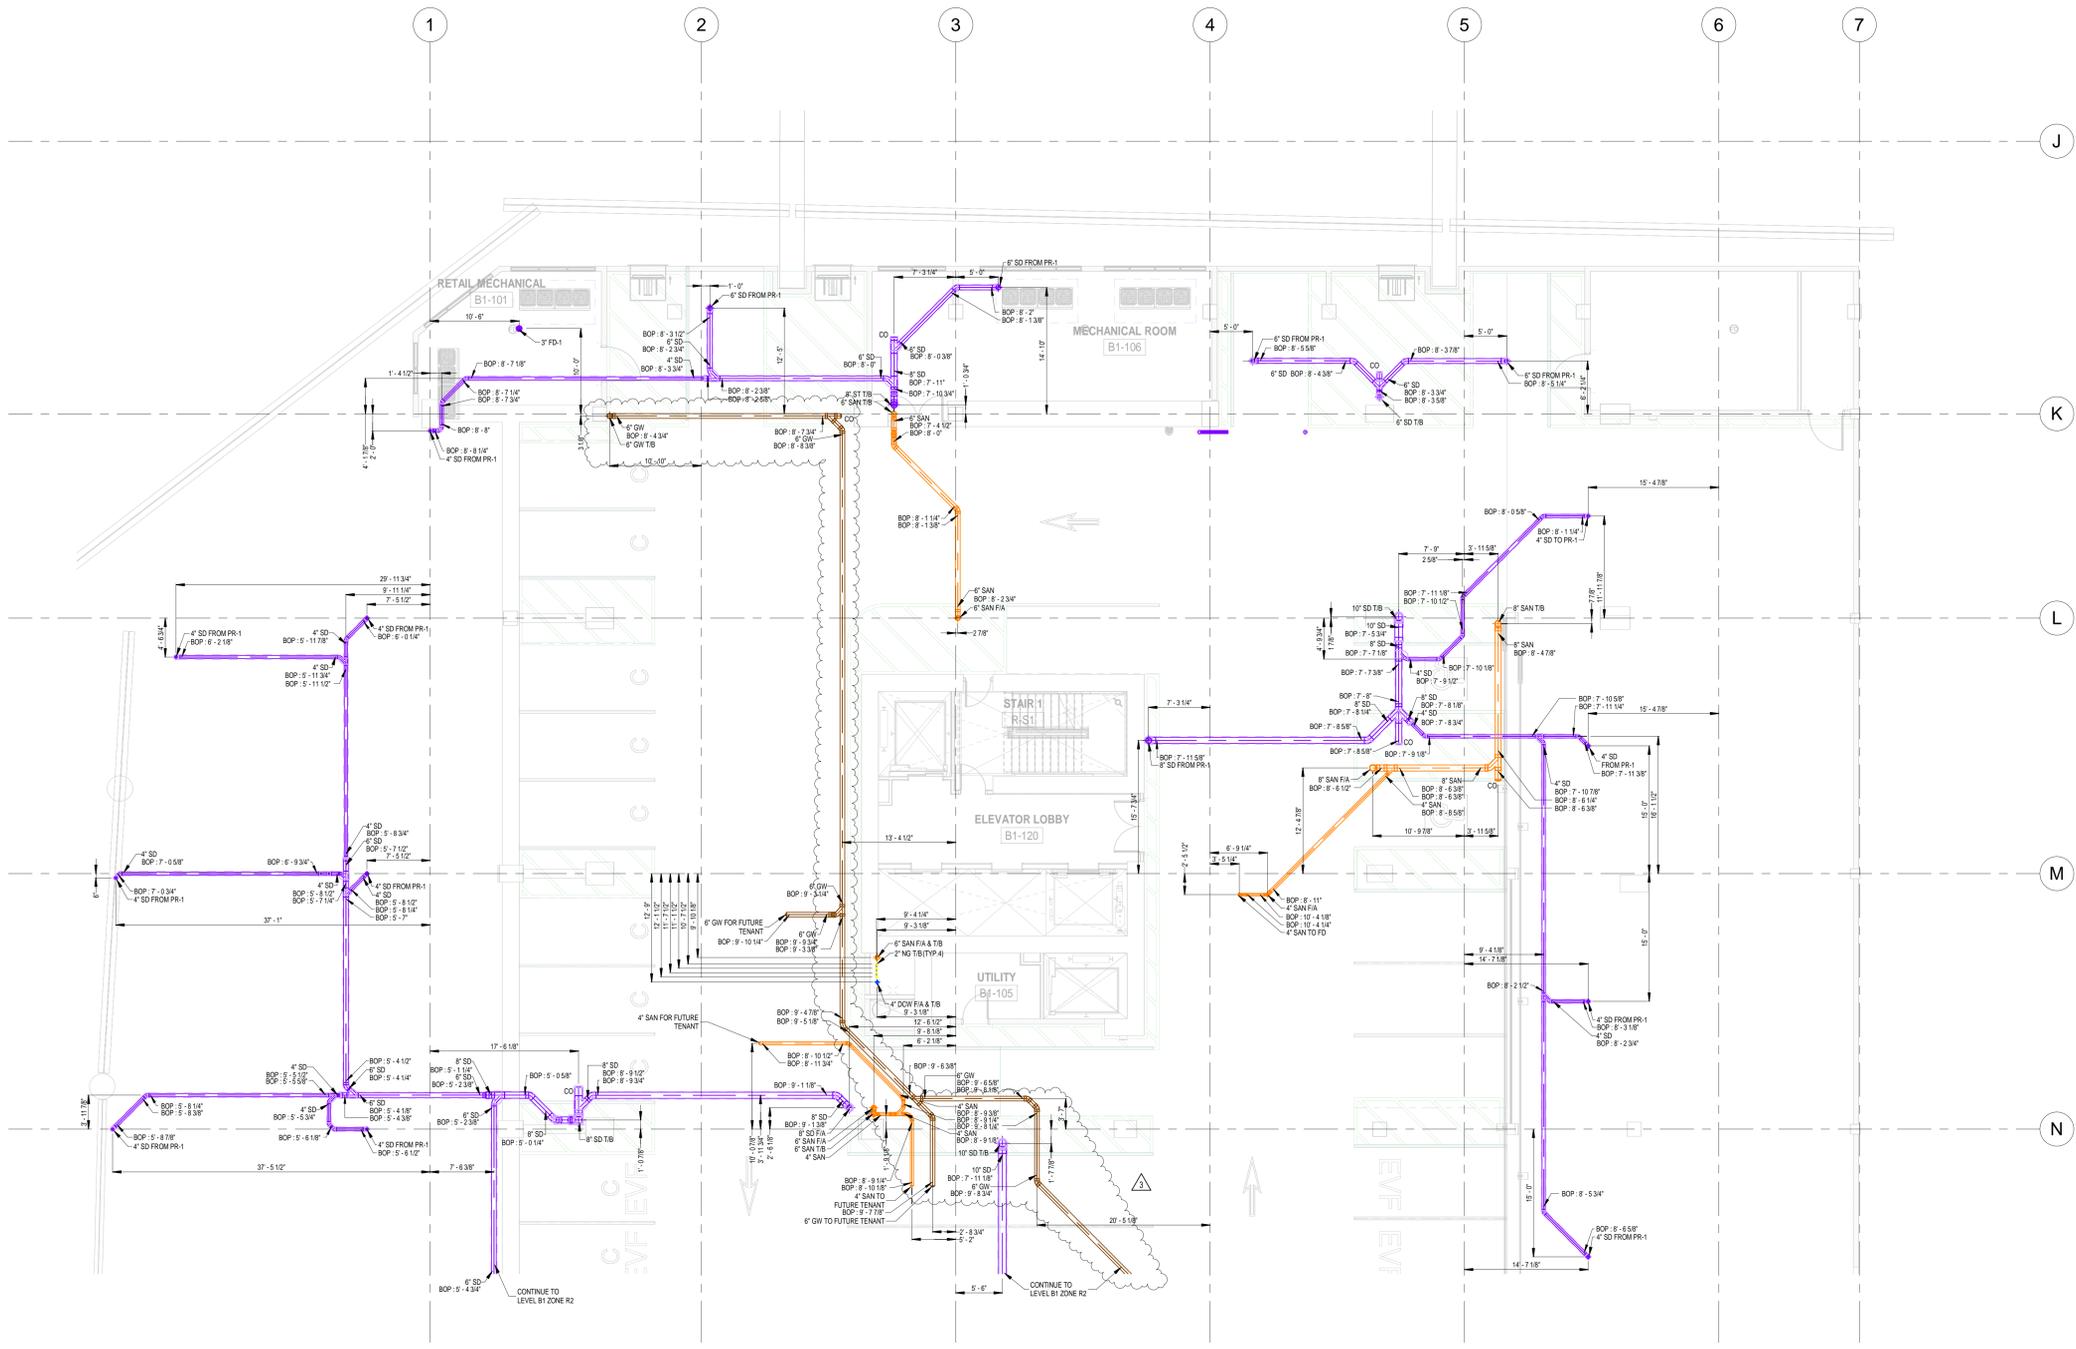

1 PLUMBING FLOOR PLAN - LEVEL B1 - ZONE R1
R-P215 1/8" = 1'-0"

GENERAL NOTES


- ALL ELEVATIONS ARE MEASURED FROM LEVEL B1 @ 1059' 0".
- ALL DIMENSIONS & ELEVATIONS ARE IN FEET AND INCHES.
- COORDINATION PROCESS IS STILL UNDER PROGRESS. PLEASE DO NOT CONSIDER THIS DRAWING AS FINAL ONE.

ABBREVIATION

SD	STORM DRAIN
BOP	BOTTOM OF PIPE
SAN	SANITARY
V	VENT
NG	NATURAL GAS
PD	PUMP DISCHARGE
GW	GREASE WASTE
FIA	FROM ABOVE
T/B	TO BELOW
F/B	FROM BELOW
FCO	FLOOR CLEANOUT
GCO	GRADE CLEANOUT
ESP-1,2,3	ELEVATOR SUMP PUMP
PR-1	PARKING DRAIN
FD-1	FLOOR DRAIN
CO	CLEAN OUT
AAV	AIR ADMITTANCE VALVE
PR-1	PROMENADE DRAIN

REV

REV	DATE	DESCRIPTION
3	07.22.2024	ISSUED FOR REVIEW
2	02.09.2024	ISSUED FOR REVIEW
1	11.20.2023	ISSUED FOR REVIEW
0	10.31.2023	ISSUED FOR REVIEW

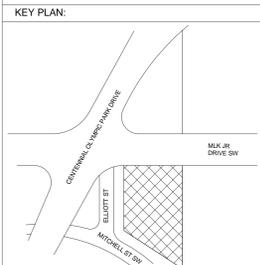


PROJECT NAME:
CENTENNIAL YARDS - HOTEL (H/E1) & RESIDENTIAL (R/E2)

AREA:
PLUMBING FLOOR PLAN - LEVEL B1 - ZONE R1

SCALE	DATE
AS MENTIONED	07.22.2024

DRAWING NUMBER:
R-P215

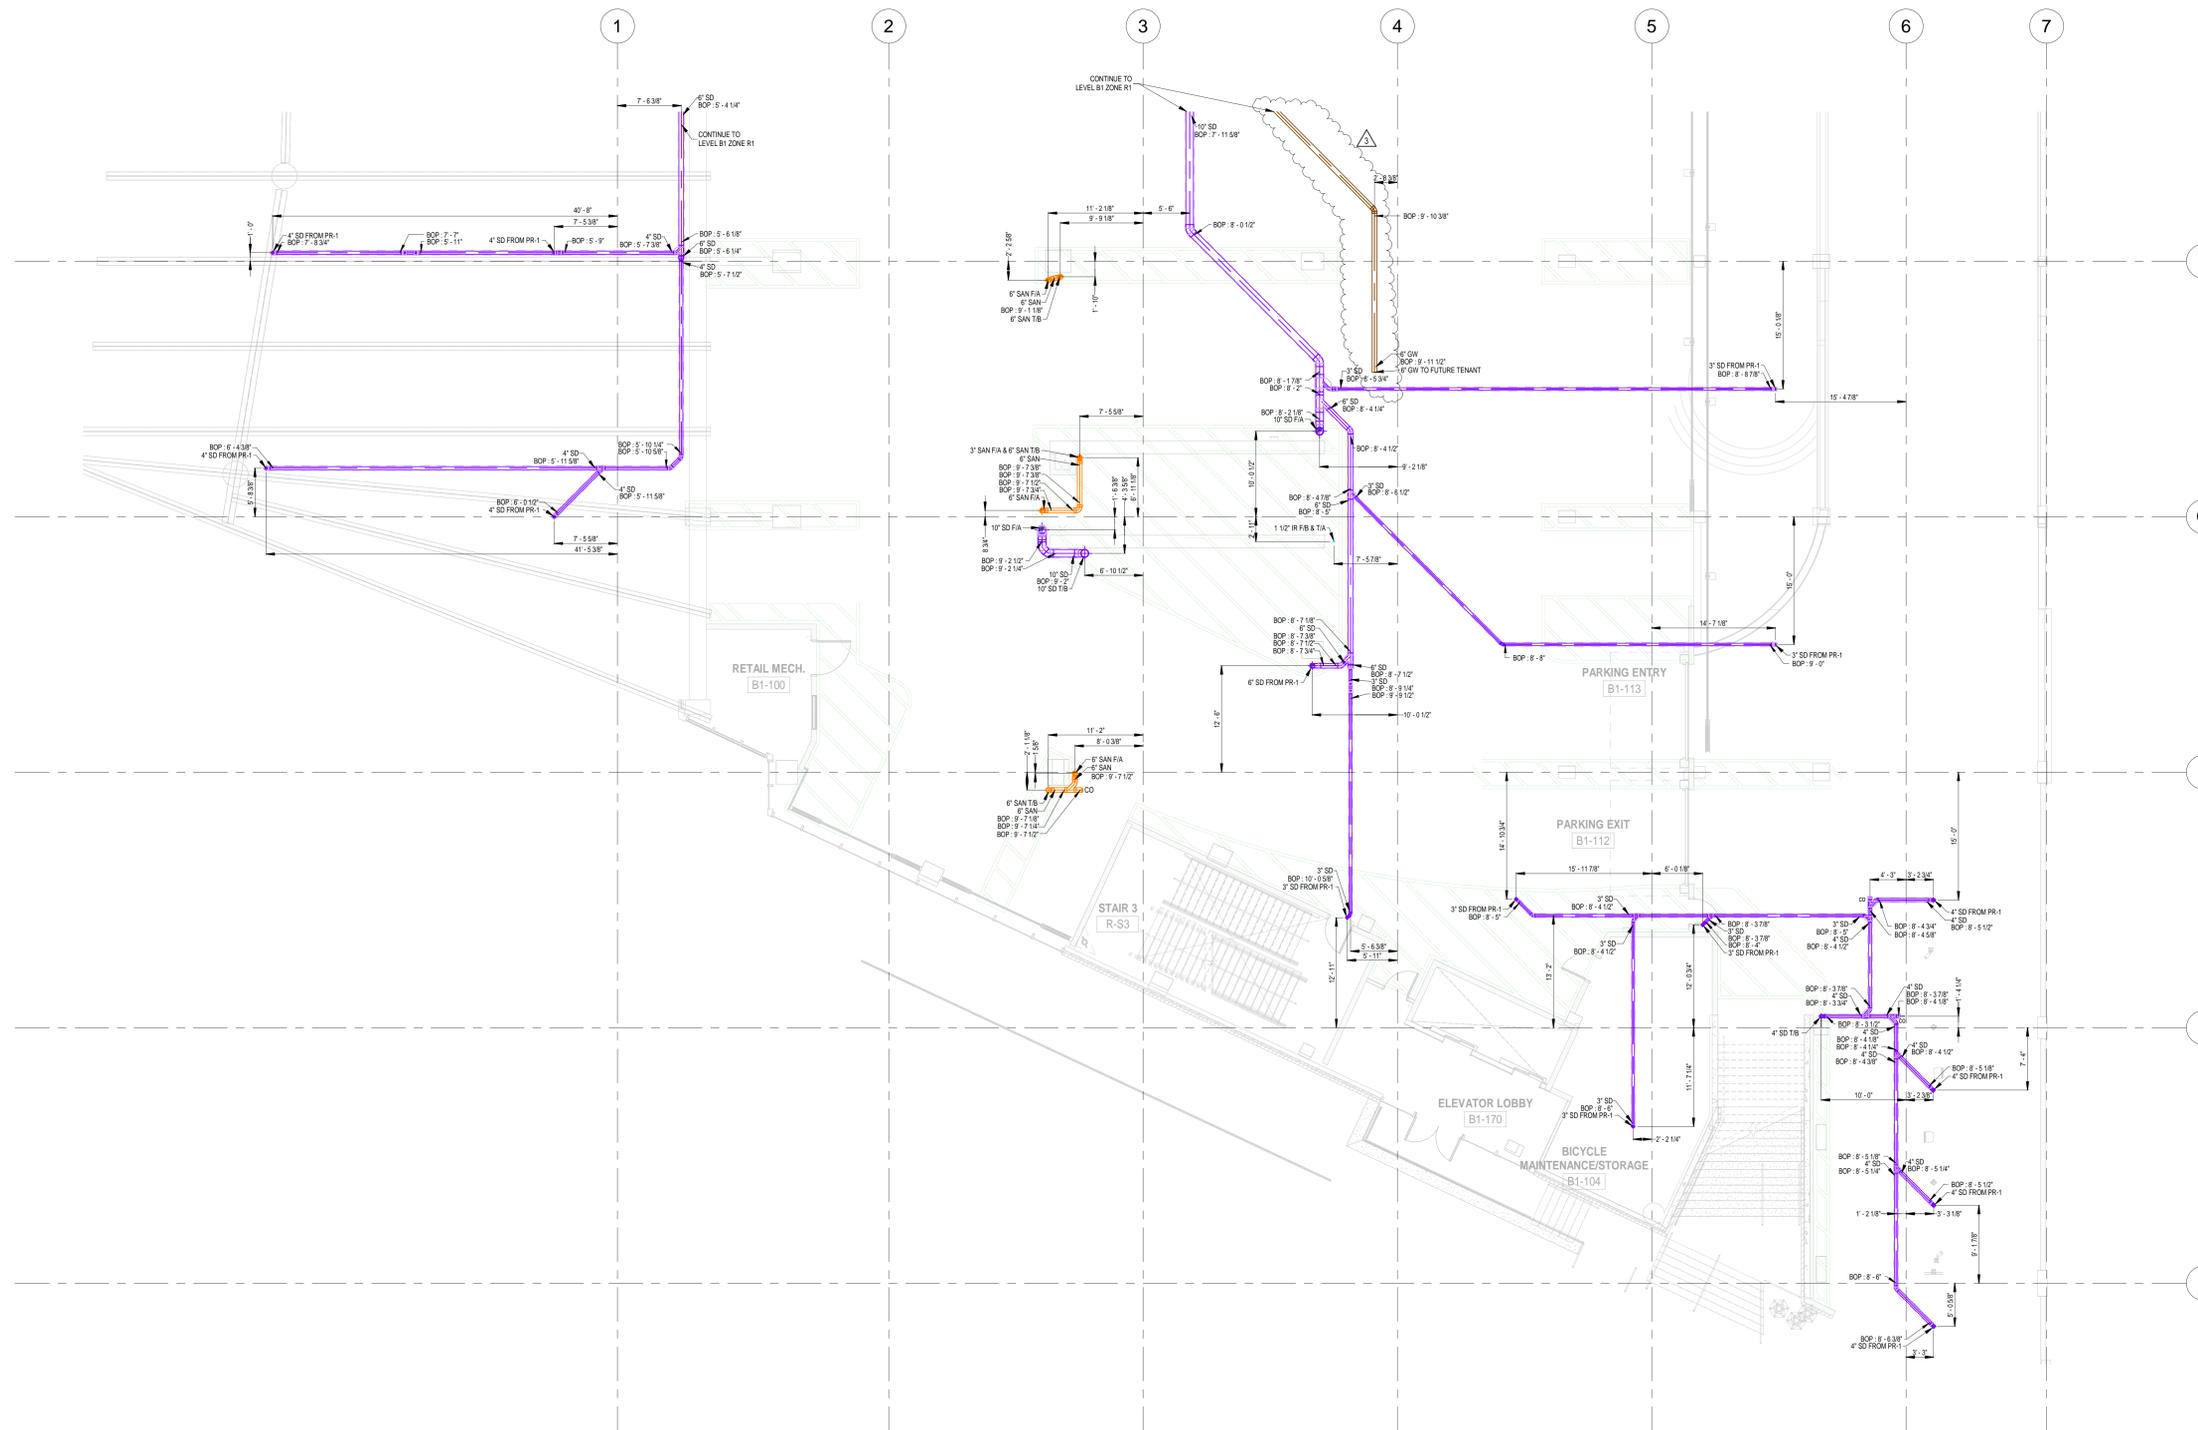

GENERAL NOTES

1. ALL ELEVATIONS ARE MEASURED FROM LEVEL B1 @ 1059' 0".
2. ALL DIMENSIONS & ELEVATIONS ARE IN FEET AND INCHES.
3. COORDINATION PROCESS IS STILL UNDER PROGRESS. PLEASE DO NOT CONSIDER THIS DRAWING AS FINAL ONE.


ABBREVIATION

SD	STORM DRAIN
BOP	BOTTOM OF PIPE
SAN	SANITARY
V	VENT
NG	NATURAL GAS
PD	PUMP DISCHARGE
GW	GREASE WASTE
F/A	FROM ABOVE
T/B	TO BELOW
F/B	FROM BELOW
FCO	FLOOR CLEANOUT
GCO	GRADE CLEANOUT
ESP-1,2,3	ELEVATOR SUMP PUMP
PD-1	PARKING DRAIN
FD-1	FLOOR DRAIN
CO	CLEAN OUT
AAV	AIR ADMITTANCE VALVE
PR-1	PROMENADE DRAIN

REV. **DATE** **DESCRIPTION**

3	07.22.2024	ISSUED FOR REVIEW
2	02.09.2024	ISSUED FOR REVIEW
1	11.20.2023	ISSUED FOR REVIEW
0	10.31.2023	ISSUED FOR REVIEW

1 PLUMBING FLOOR PLAN - LEVEL B1 - ZONE R2
R-P216 1/8" = 1'-0"

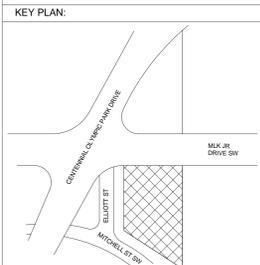


PROJECT NAME:
CENTENNIAL YARDS - HOTEL (H/E1) & RESIDENTIAL (R/E2)

AREA:
PLUMBING FLOOR PLAN - LEVEL B1 - ZONE R2

SCALE	DATE
AS MENTIONED	07.22.2024

DRAWING NUMBER:
R-P216

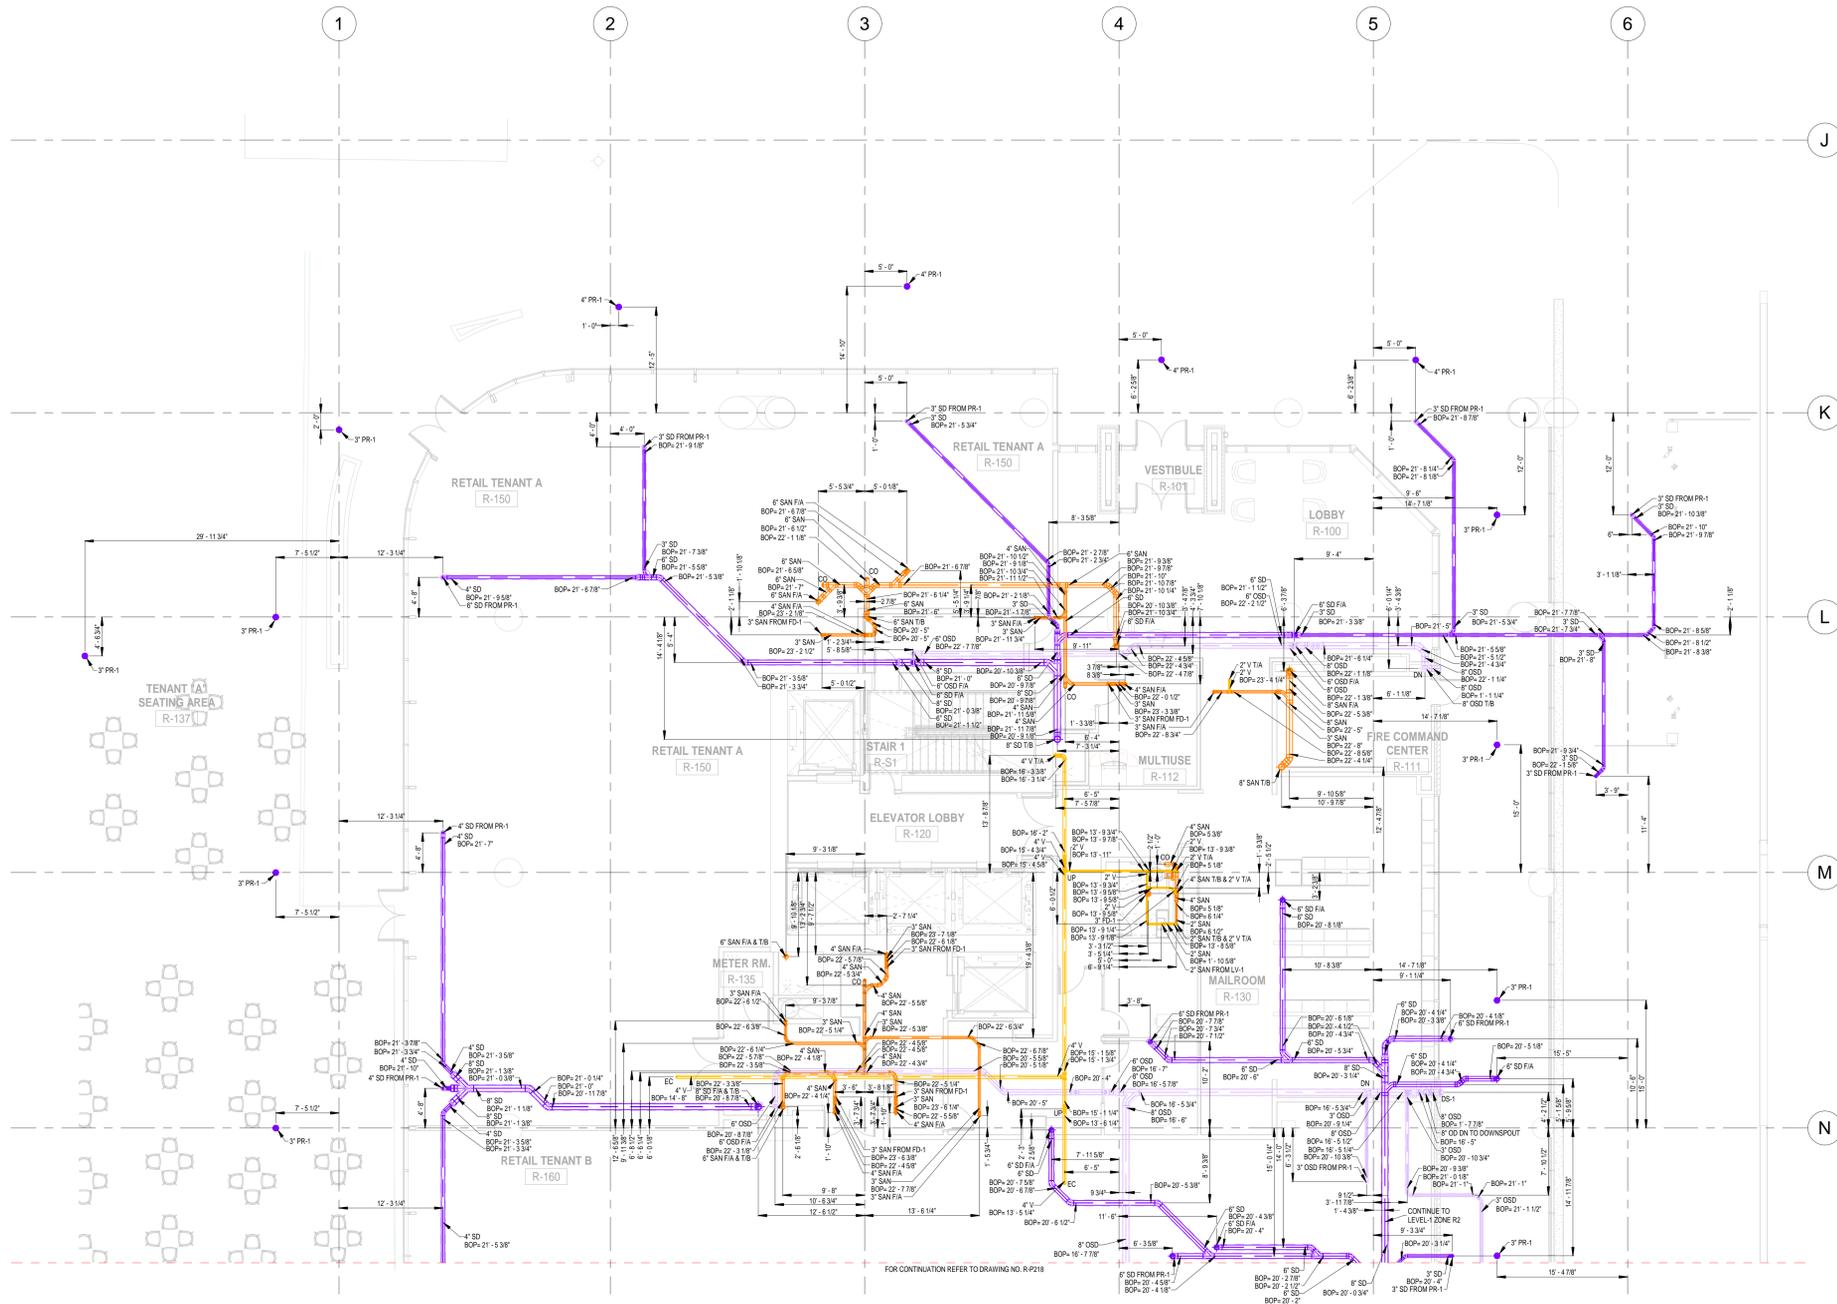

GENERAL NOTES

1. ALL ELEVATIONS ARE MEASURED FROM LEVEL 01 @ .1071' 4".
2. ALL DIMENSIONS & ELEVATIONS ARE IN FEET AND INCHES.
3. COORDINATION PROCESS IS STILL UNDER PROGRESS. PLEASE DO NOT CONSIDER THIS DRAWING AS FINAL ONE.


ABBREVIATION

SD	STORM DRAIN
PR	PROMENADE DRAIN
SAN	SANITARY
V	VENT
BOP	BOTTOM OF PIPE
FD	FLOOR DRAIN
FIA	FROM ABOVE
T/B	TO BELOW
T/A	TO ABOVE
DN	DOWN
OSD	OVERFLOW STORM DRAIN
PRL	PRESSURE RELIEF LINE
HD	HUB DRAIN

REV. DATE DESCRIPTION

0	02.28.2024	ISSUED FOR REVIEW
---	------------	-------------------

1 PLUMBING SANITARY LEVEL 1 - ZONE R1
R-P217 1/8" = 1'-0"

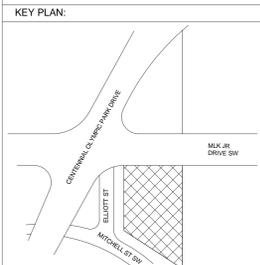

PROJECT NAME:
CENTENNIAL YARDS - HOTEL (H/E1) & RESIDENTIAL (R/E2)

AREA:
PLUMBING SANITARY LEVEL 1 - ZONE R1

SCALE	DATE
AS MENTIONED	02.28.2024


DRAWING NUMBER:
R-P217

GENERAL NOTES

1. ALL ELEVATIONS ARE MEASURED FROM LEVEL 01 @ 107'1" 4".
2. ALL DIMENSIONS & ELEVATIONS ARE IN FEET AND INCHES.
3. COORDINATION PROCESS IS STILL UNDER PROGRESS. PLEASE DO NOT CONSIDER THIS DRAWING AS FINAL ONE.

ABBREVIATION


SD	STORM DRAIN
PR	PROMENADE DRAIN
SAN	SANITARY
V	VENT
BOP	BOTTOM OF PIPE
FD	FLOOR DRAIN
F/A	FROM ABOVE
T/B	TO BELOW
T/A	TO ABOVE
DN	DOWN
OSD	OVERFLOW STORM DRAIN
PRL	PRESSURE RELIEF LINE
HD	HUB DRAIN

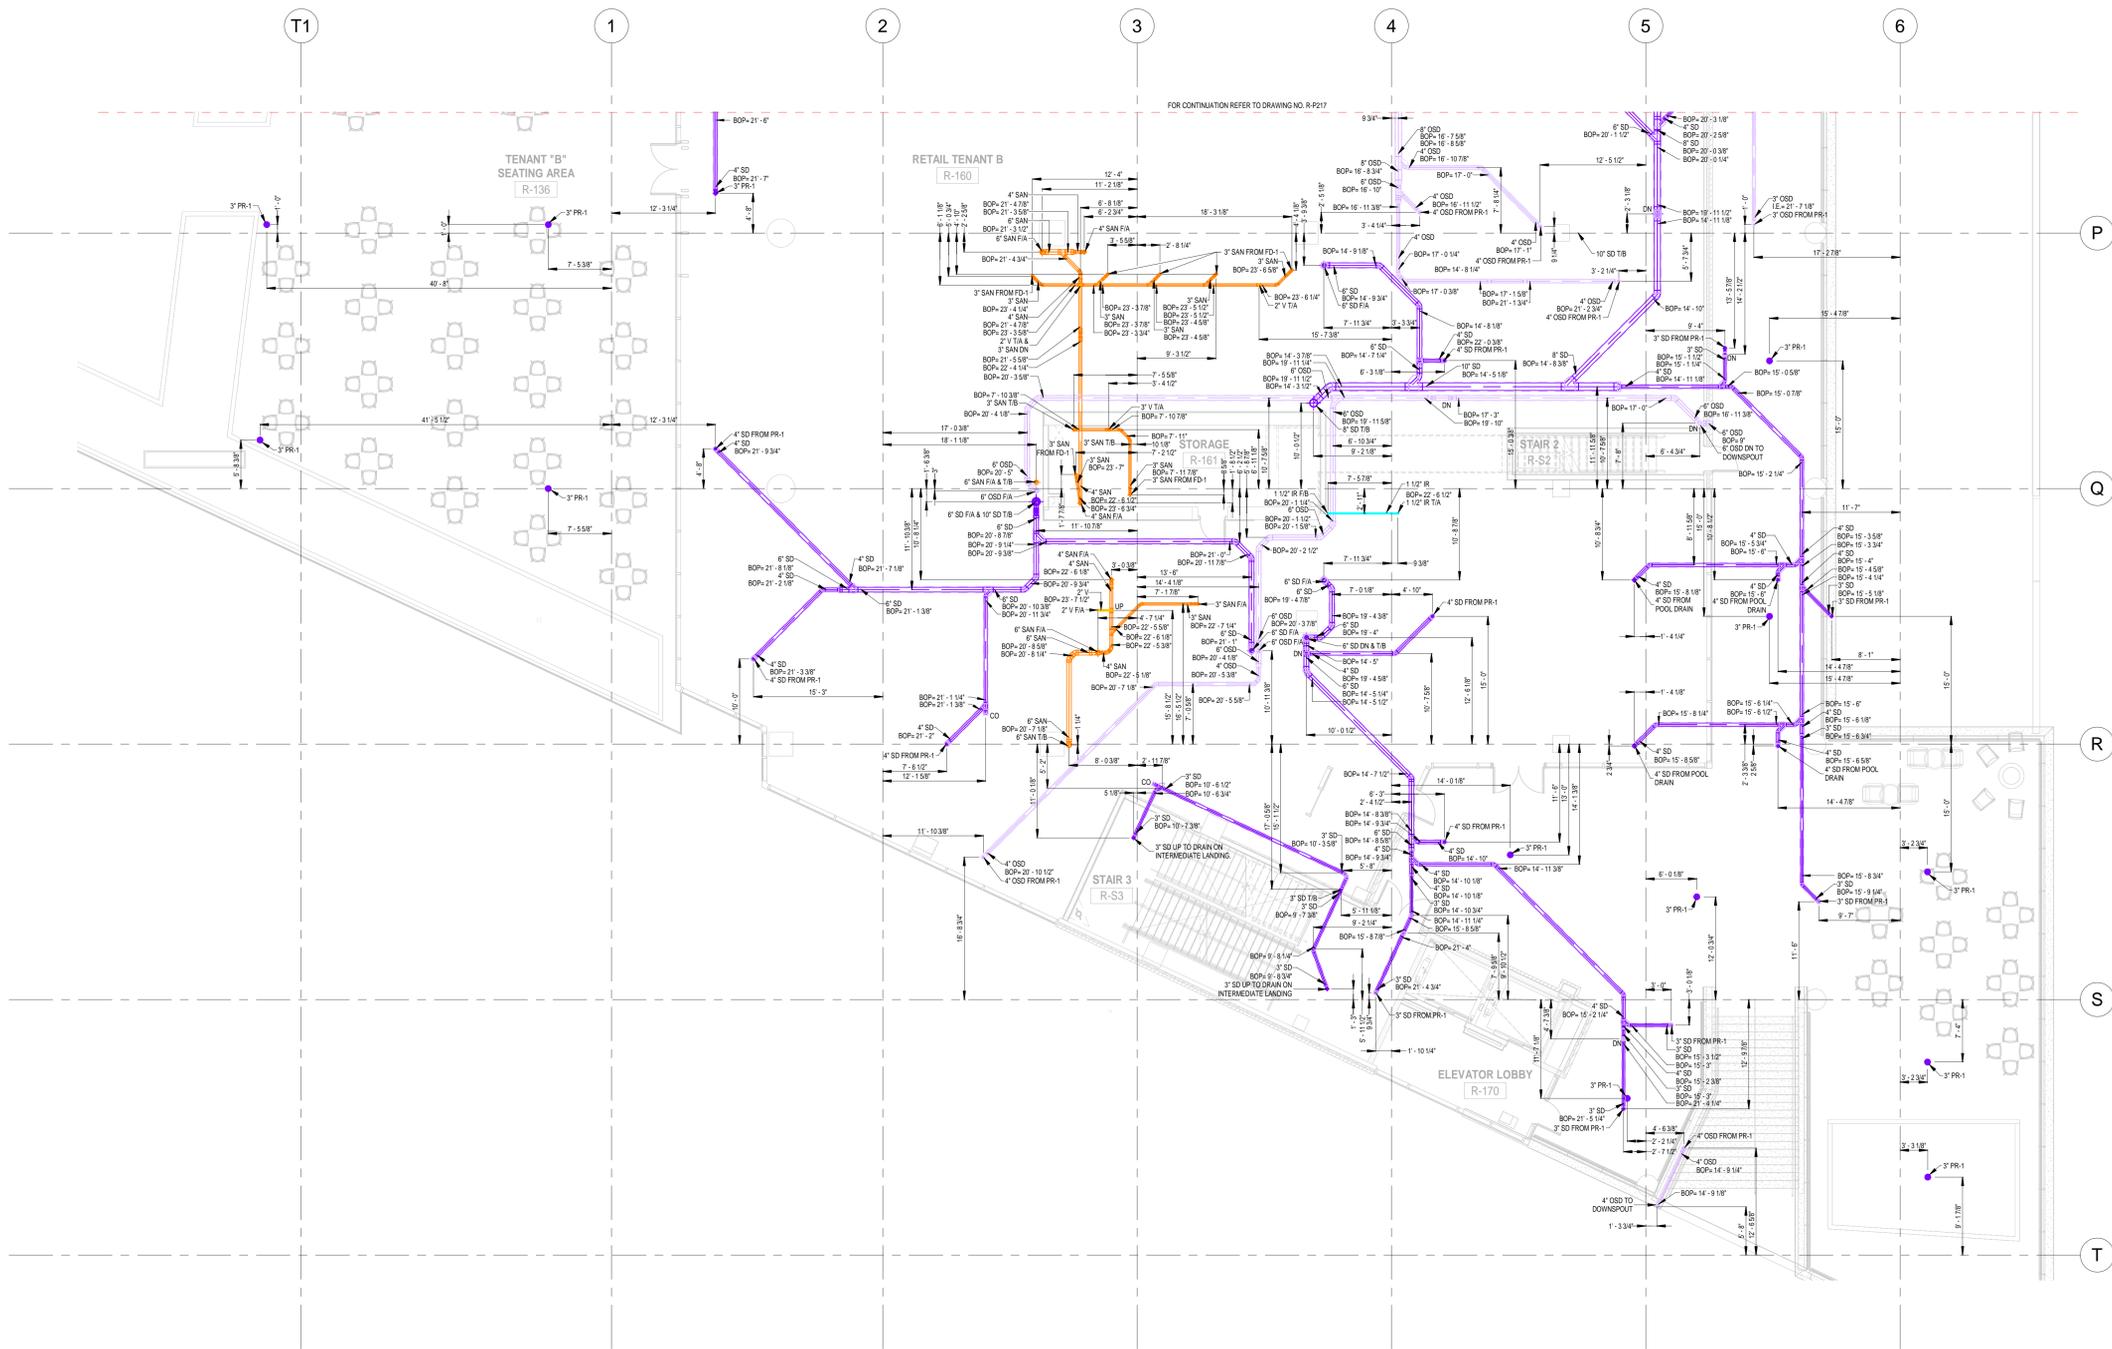

1 PLUMBING SANITARY LEVEL 1 - ZONE R2
R-P218 1/8" = 1'-0"

REV. DATE DESCRIPTION

0	02.28.2024	ISSUED FOR REVIEW
---	------------	-------------------

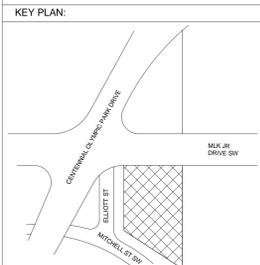

PROJECT NAME:
CENTENNIAL YARDS - HOTEL (H/E1) & RESIDENTIAL (R/E2)

AREA:
PLUMBING SANITARY LEVEL 1 - ZONE R2

SCALE	DATE
AS MENTIONED	02.28.2024

DRAWING NUMBER:
R-P218

GENERAL NOTES

- ALL ELEVATIONS ARE MEASURED FROM LEVEL 02 @ 1086' 0".
- ALL DIMENSIONS & ELEVATIONS ARE IN FEET AND INCHES.
- COORDINATION PROCESS IS STILL UNDER PROGRESS. PLEASE DO NOT CONSIDER THIS DRAWING AS FINAL ONE.


KEY NOTES

- ① 6" SAN T/B
- ② 3" SAN FROM HD
- ③ 3" SAN FROM WC
- ④ 2" SAN FROM LAV
- ⑤ 2" SAN FROM WASHING MACHINE
- ⑥ 2" SAN FROM KITCHEN SINK
- ⑦ 2" SAN FROM SHOWER
- ⑧ 2" SAN FROM BATH TUB
- ⑨ 3" SAN F/A
- ⑩ 3" PRL T/A
- ⑪ 4" SAN F/A
- ⑫ 4" SAN T/B
- ⑬ 3" SAN F/A & T/B
- ⑭ 2" V UP
- ⑮ 6" SAN F/A
- ⑯ 6" SD F/A
- ⑰ 6" SD T/B
- ⑱ 6" OSD F/A
- ⑲ 6" OSD T/B
- ⑳ 3" SAN T/B
- ㉑ 2" V F/B
- ㉒ 8" SD T/B

ABBREVIATION

SD	STORM DRAIN
PR	PROMENADE DRAIN
SAN	SANITARY
V	VENT
BOP	BOTTOM OF PIPE
FD	FLOOR DRAIN
OSD	OVERFLOW STORM DRAIN
PRL	PRESSURE RELIEF LINE
HD	HUB DRAIN

REV.	DATE	DESCRIPTION
0	04.10.2024	ISSUED FOR REVIEW





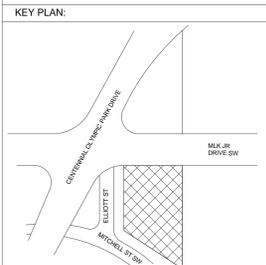


PROJECT NAME:
CENTENNIAL YARDS - HOTEL (H/E1) & RESIDENTIAL (R/E2)

AREA:
PLUMBING SANITARY LEVEL 2 ZONE -R1 CALLOUT

SCALE	DATE
AS MENTIONED	04.10.2024

DRAWING NUMBER:
R-P2A

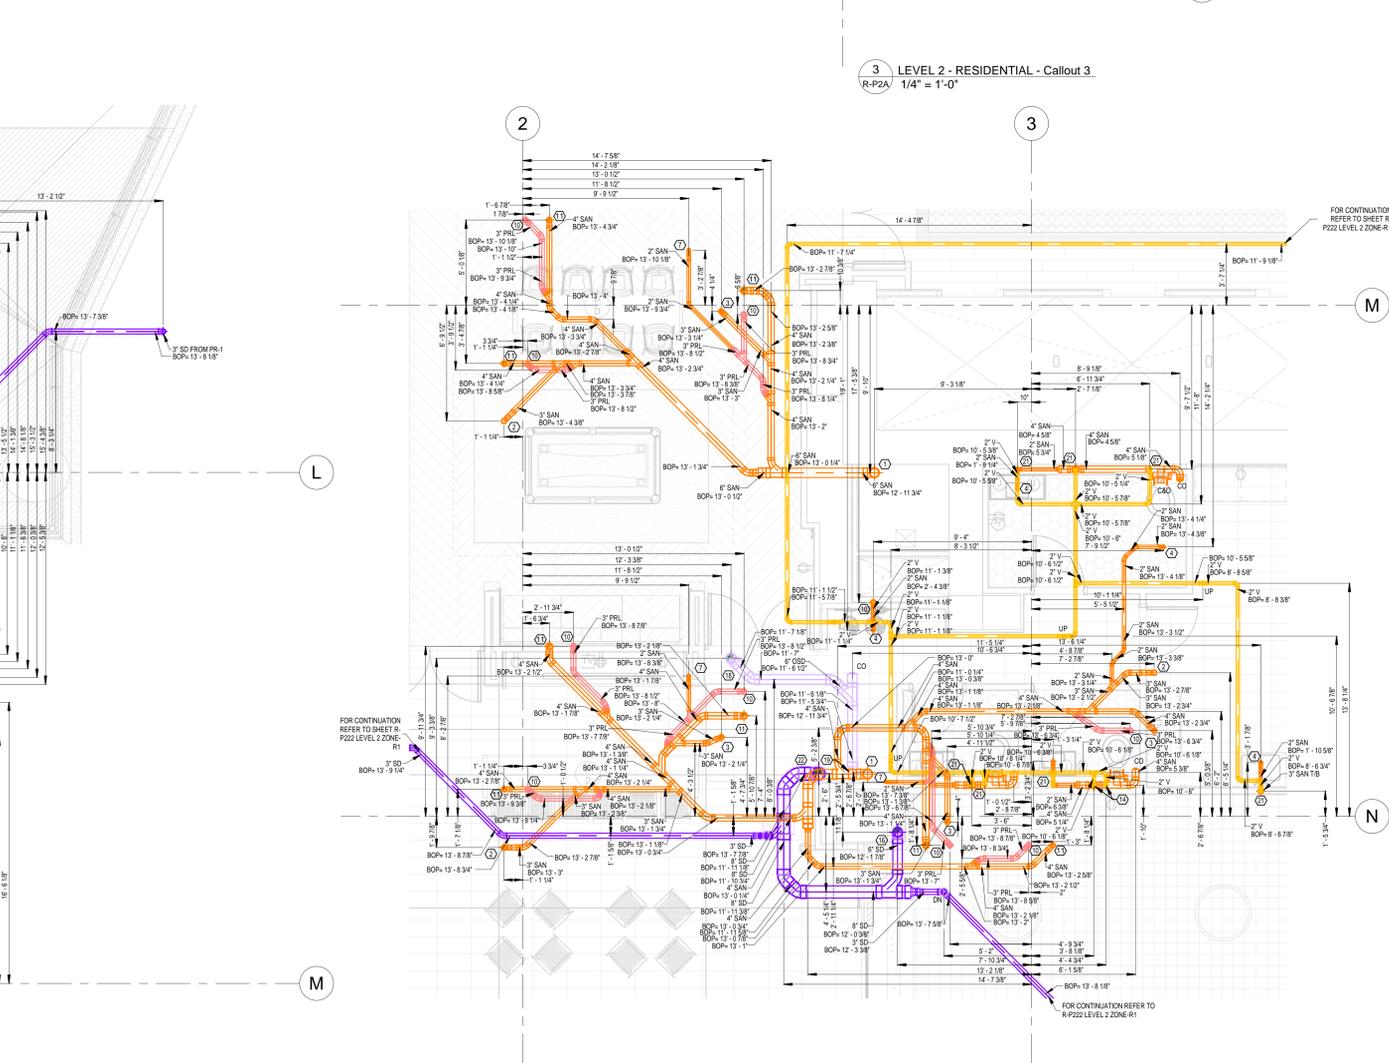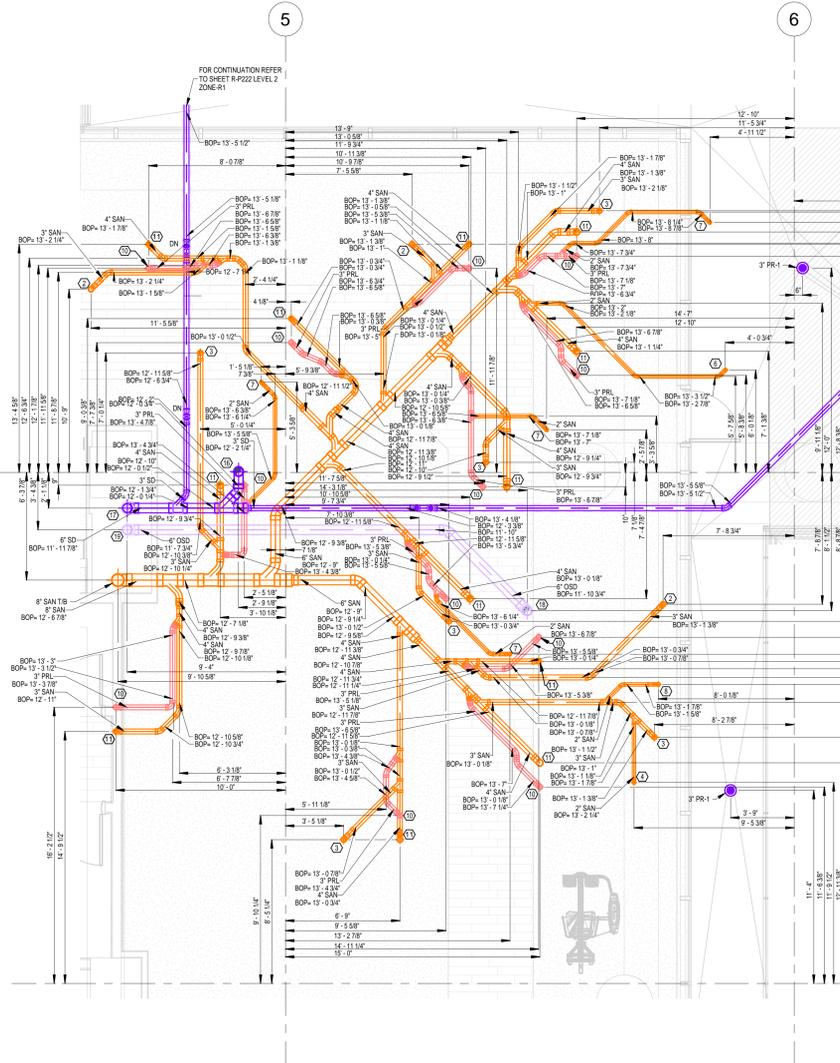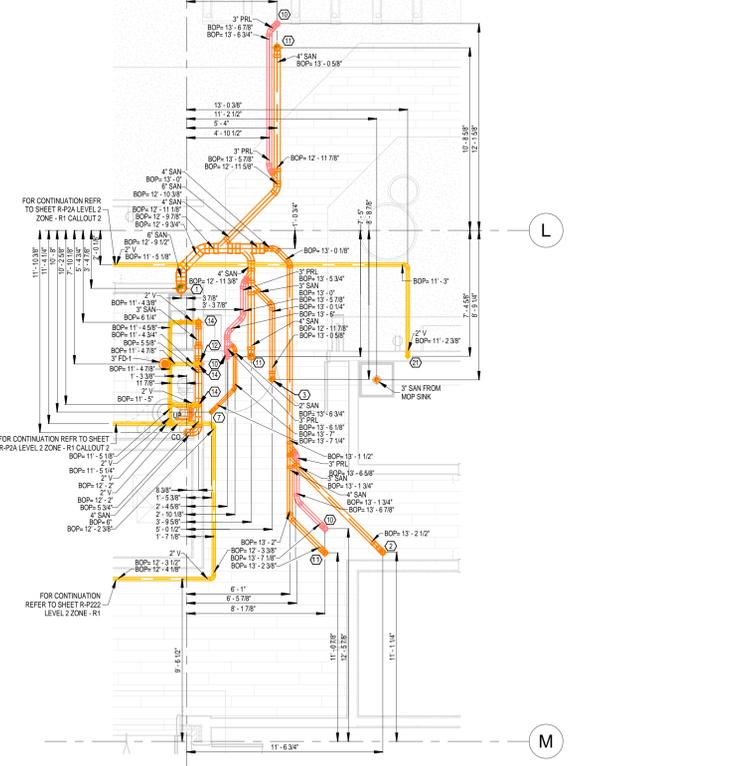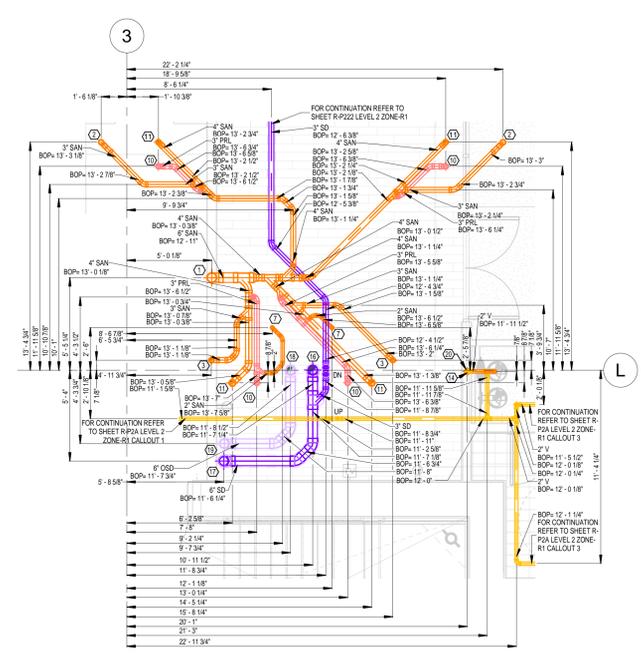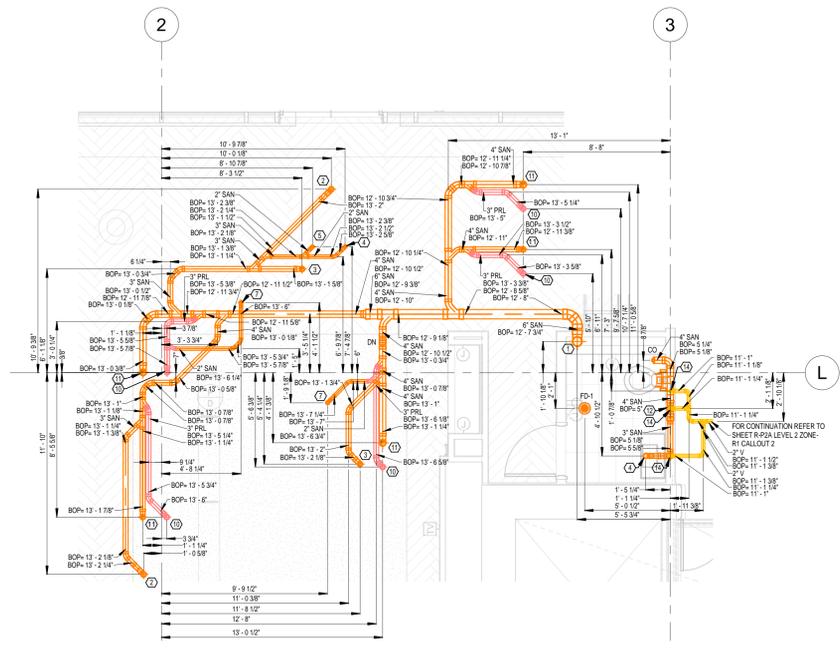

1 LEVEL 2 - RESIDENTIAL - Callout 1
R-P2A 1/4" = 1'-0"

2 LEVEL 2 - RESIDENTIAL - Callout 2
R-P2A 1/4" = 1'-0"

3 LEVEL 2 - RESIDENTIAL - Callout 3
R-P2A 1/4" = 1'-0"

4 LEVEL 2 - RESIDENTIAL - Callout 4
R-P2A 1/4" = 1'-0"

5 LEVEL 2 - RESIDENTIAL - Callout 5
R-P2A 1/4" = 1'-0"

GENERAL NOTES



- ALL ELEVATIONS ARE MEASURED FROM LEVEL 02 @ 100' 0".
- ALL DIMENSIONS & ELEVATIONS ARE IN FEET AND INCHES.
- COORDINATION PROCESS IS STILL UNDER PROGRESS. PLEASE DO NOT CONSIDER THIS DRAWING AS FINAL ONE.

KEY NOTES

①	6" SAN T/B
②	3" SAN FROM HD
③	3" SAN FROM WC
④	2" SAN FROM LAV
⑤	2" SAN FROM WASHING MACHINE
⑥	2" SAN FROM KITCHEN SINK
⑦	2" SAN FROM SHOWER
⑧	2" SAN FROM BATH TUB
⑨	3" SAN F/A
⑩	3" PRL T/A
⑪	4" SAN F/A
⑫	4" SAN T/B
⑬	3" SAN F/A & T/B
⑭	2" V UP
⑮	6" SAN F/A
⑯	6" SD F/A
⑰	6" OSD F/A
⑱	6" OSD T/B
⑲	3" SAN T/B
⑳	2" V F/B
㉑	8" SD T/B

ABBREVIATION

SD	STORM DRAIN
PR	PROMENADE DRAIN
SAN	SANITARY
V	VENT
BOP	BOTTOM OF PIPE
FD	FLOOR DRAIN
OSD	OVERFLOW STORM DRAIN
PRL	PRESSURE RELIEF LINE
HD	HUB DRAIN

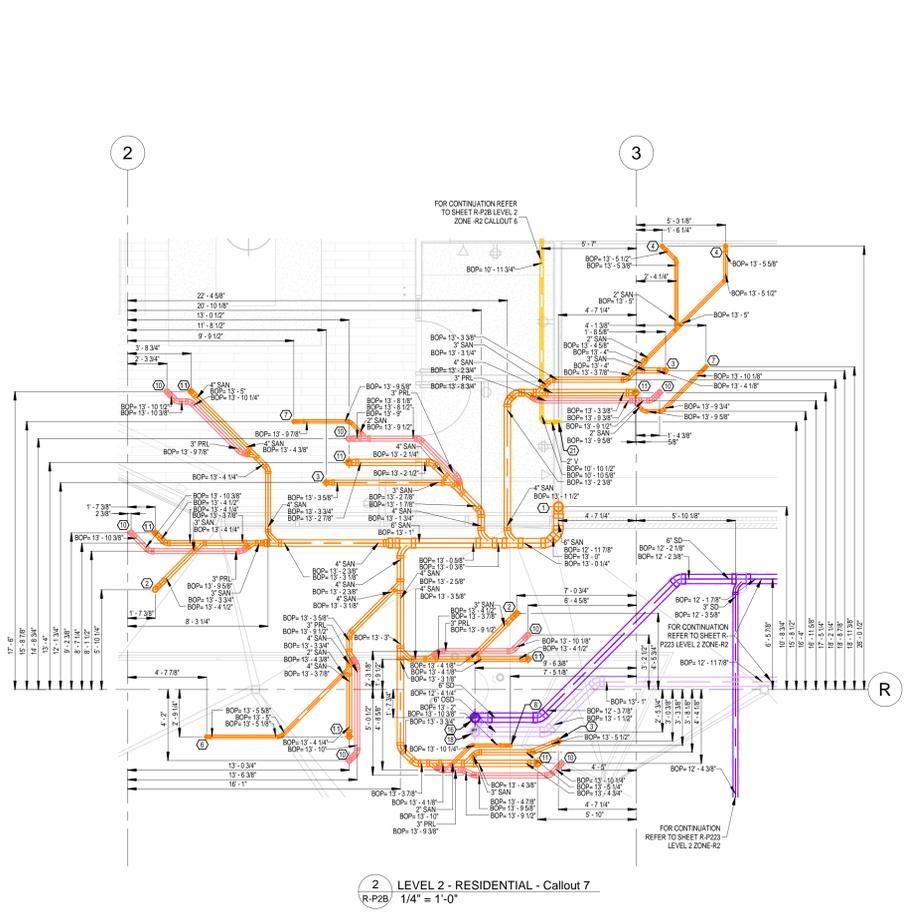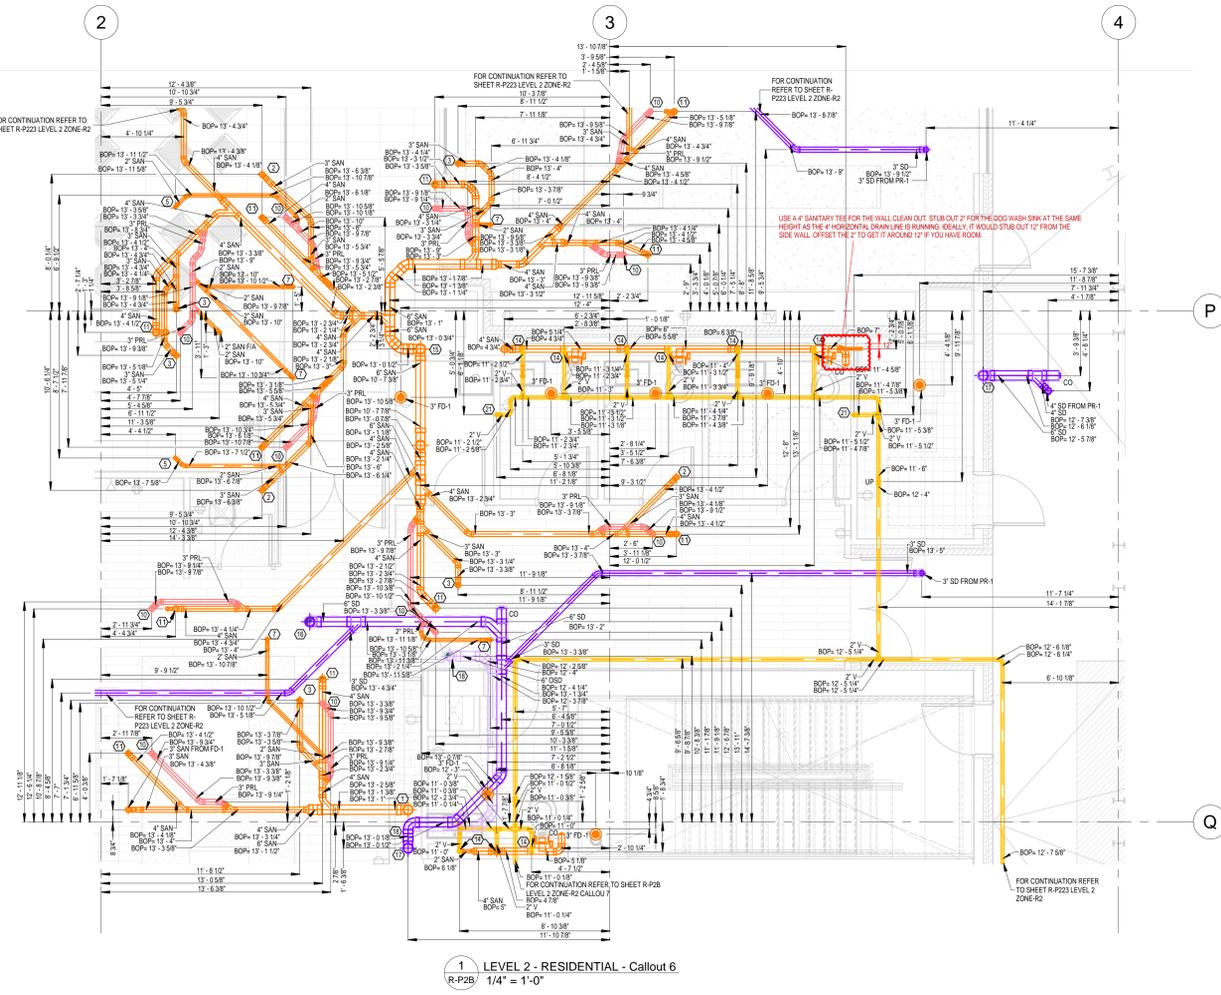

REV.	DATE	DESCRIPTION
0	04.10.2024	ISSUED FOR REVIEW



PROJECT NAME:
CENTENNIAL YARDS - HOTEL (H/E1) & RESIDENTIAL (R/E2)

AREA:
PLUMBING SANITARY LEVEL 2 ZONE -R2 CALLOUT

SCALE: AS MENTIONED

DATE: 04.10.2024

DRAWING NUMBER:
R-P2B

GENERAL NOTES

- ALL ELEVATIONS ARE MEASURED FROM LEVEL 02 @ 1096' 0".
- ALL DIMENSIONS & ELEVATIONS ARE IN FEET AND INCHES.
- COORDINATION PROCESS IS STILL UNDER PROGRESS. PLEASE DO NOT CONSIDER THIS DRAWING AS FINAL ONE.

ABBREVIATION


NG	NATURAL GAS
DCW	DOMESTIC COLD WATER
DHW	DOMESTIC HOT WATER
T/B	TO BELOW
BOP	BOTTOM OF PIPE
T/A	TO ABOVE
F/A	FROM ABOVE
DN	DOWN
LAV	LAVATORY
WC	WATER CLOSET



1 PLUMBING SUPPLY LEVEL 2 - ZONE R1
R-P235 1/8" = 1'-0"

REV. DATE DESCRIPTION

0	05.30.2024	ISSUED FOR REVIEW
---	------------	-------------------

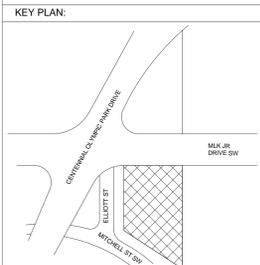

PROJECT NAME:
CENTENNIAL YARDS - HOTEL (H/E1) & RESIDENTIAL (R/E2)

AREA:
PLUMBING SUPPLY LEVEL 2 - ZONE R1

SCALE	DATE
AS MENTIONED	05.30.2024

DRAWING NUMBER:
R-P235


GENERAL NOTES

1. ALL ELEVATIONS ARE MEASURED FROM LEVEL 02 @ 1096' 0".
2. ALL DIMENSIONS & ELEVATIONS ARE IN FEET AND INCHES.
3. COORDINATION PROCESS IS STILL UNDER PROGRESS. PLEASE DO NOT CONSIDER THIS DRAWING AS FINAL ONE.

ABBREVIATION

NG	NATURAL GAS
DCW	DOMESTIC COLD WATER
DHW	DOMESTIC HOT WATER
T/B	TO BELOW
BOP	BOTTOM OF PIPE
T/A	TO ABOVE
F/A	FROM ABOVE
DN	DOWN
LAV	LAVATORY
WC	WATER CLOSET

REV.	DATE	DESCRIPTION
0	05.30.2024	ISSUED FOR REVIEW

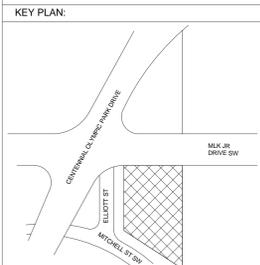

PROJECT NAME:
CENTENNIAL YARDS - HOTEL (H/E1) & RESIDENTIAL (R/E2)


AREA:
PLUMBING SUPPLY LEVEL 2 - ZONE R2

SCALE	DATE
AS MENTIONED	05.30.2024

DRAWING NUMBER:
R-P236



1 PLUMBING SUPPLY LEVEL 2 - ZONE R2
R-P236 1/8" = 1'-0"

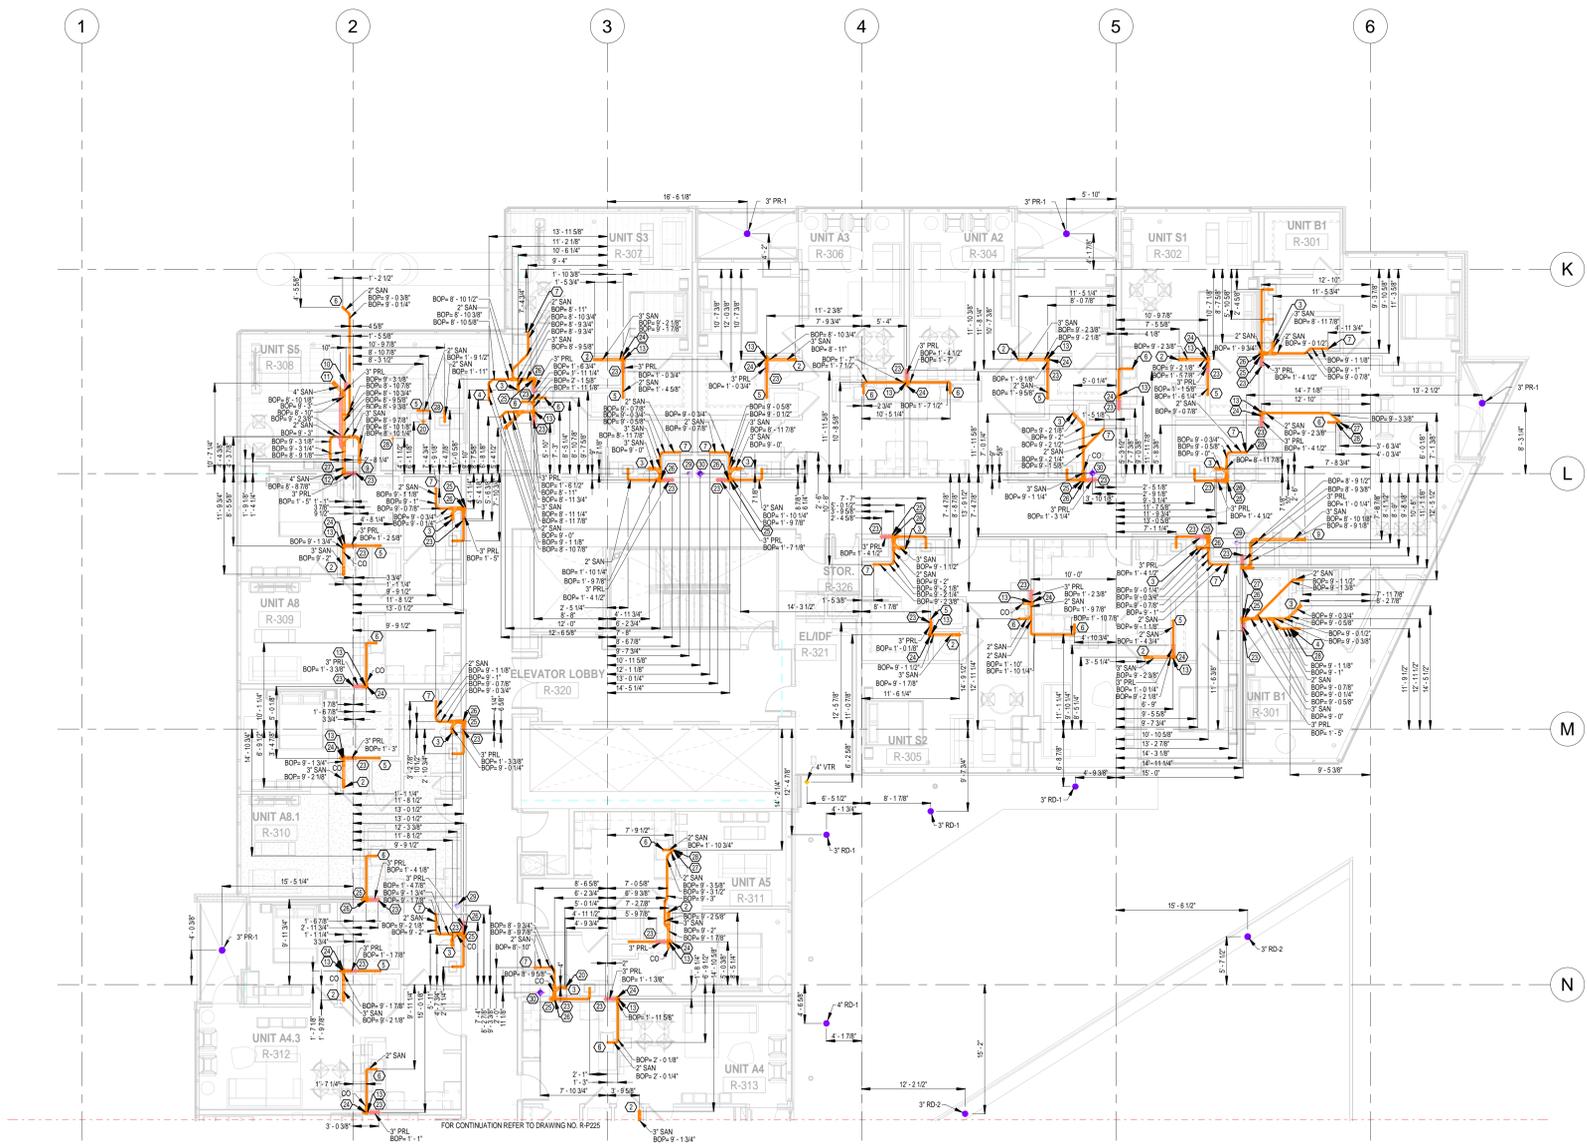

1 PLUMBING SANITARY LEVEL 3 - ZONE R1
R-P224 1/8" = 1'-0"

GENERAL NOTES

- ALL ELEVATIONS ARE MEASURED FROM LEVEL 03@1111' 0".
- ALL DIMENSIONS & ELEVATIONS ARE IN FEET AND INCHES.
- COORDINATION PROCESS IS STILL UNDER PROGRESS. PLEASE DO NOT CONSIDER THIS DRAWING AS FINAL ONE.


ABBREVIATION

SD	STORM DRAIN
PR	PROMENADE DRAIN
SAN	SANITARY
V	VENT
BOP	BOTTOM OF PIPE
FD	FLOOR DRAIN
OSD	OVERFLOW STORM DRAIN
PRL	PRESSURE RELIEF LINE
HD	HUB DRAIN

KEY NOTES

①	6" SAN T/B
②	3" SAN FROM HD
③	3" SAN FROM WC
④	2" SAN FROM LAV
⑤	2" SAN FROM WASHING MACHINE
⑥	2" SAN FROM KITCHEN SINK
⑦	2" SAN FROM SHOWER
⑧	2" SAN FROM BATH TUB
⑨	3" SAN F/A
⑩	3" PRL T/A
⑪	4" SAN F/A
⑫	4" SAN T/B
⑬	3" SAN F/A & T/B
⑭	2" V UP
⑮	6" SAN F/A
⑯	6" SD F/A
⑰	6" SD T/B
⑱	6" OSD F/A
⑲	6" OSD T/B
⑳	3" SAN T/B
㉑	2" V F/B
㉒	8" SD T/B
㉓	3" PRL FROM DEAEATOR T/B
㉔	3" AERATOR
㉕	4" AERATOR
㉖	4" SAN F/A & T/B
㉗	2" SAN F/A
㉘	2" SAN T/B
㉙	6" OSD F/A & T/B
㉚	6" SD F/A & T/B

REV.	DATE	DESCRIPTION
0	04.30.2024	ISSUED FOR REVIEW

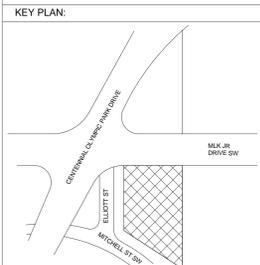


PROJECT NAME:
CENTENNIAL YARDS - HOTEL (H/E1) & RESIDENTIAL (R/E2)

AREA:
PLUMBING SANITARY LEVEL 3 ZONE -R1

SCALE	DATE
AS MENTIONED	04.30.2024

DRAWING NUMBER:
R-P224

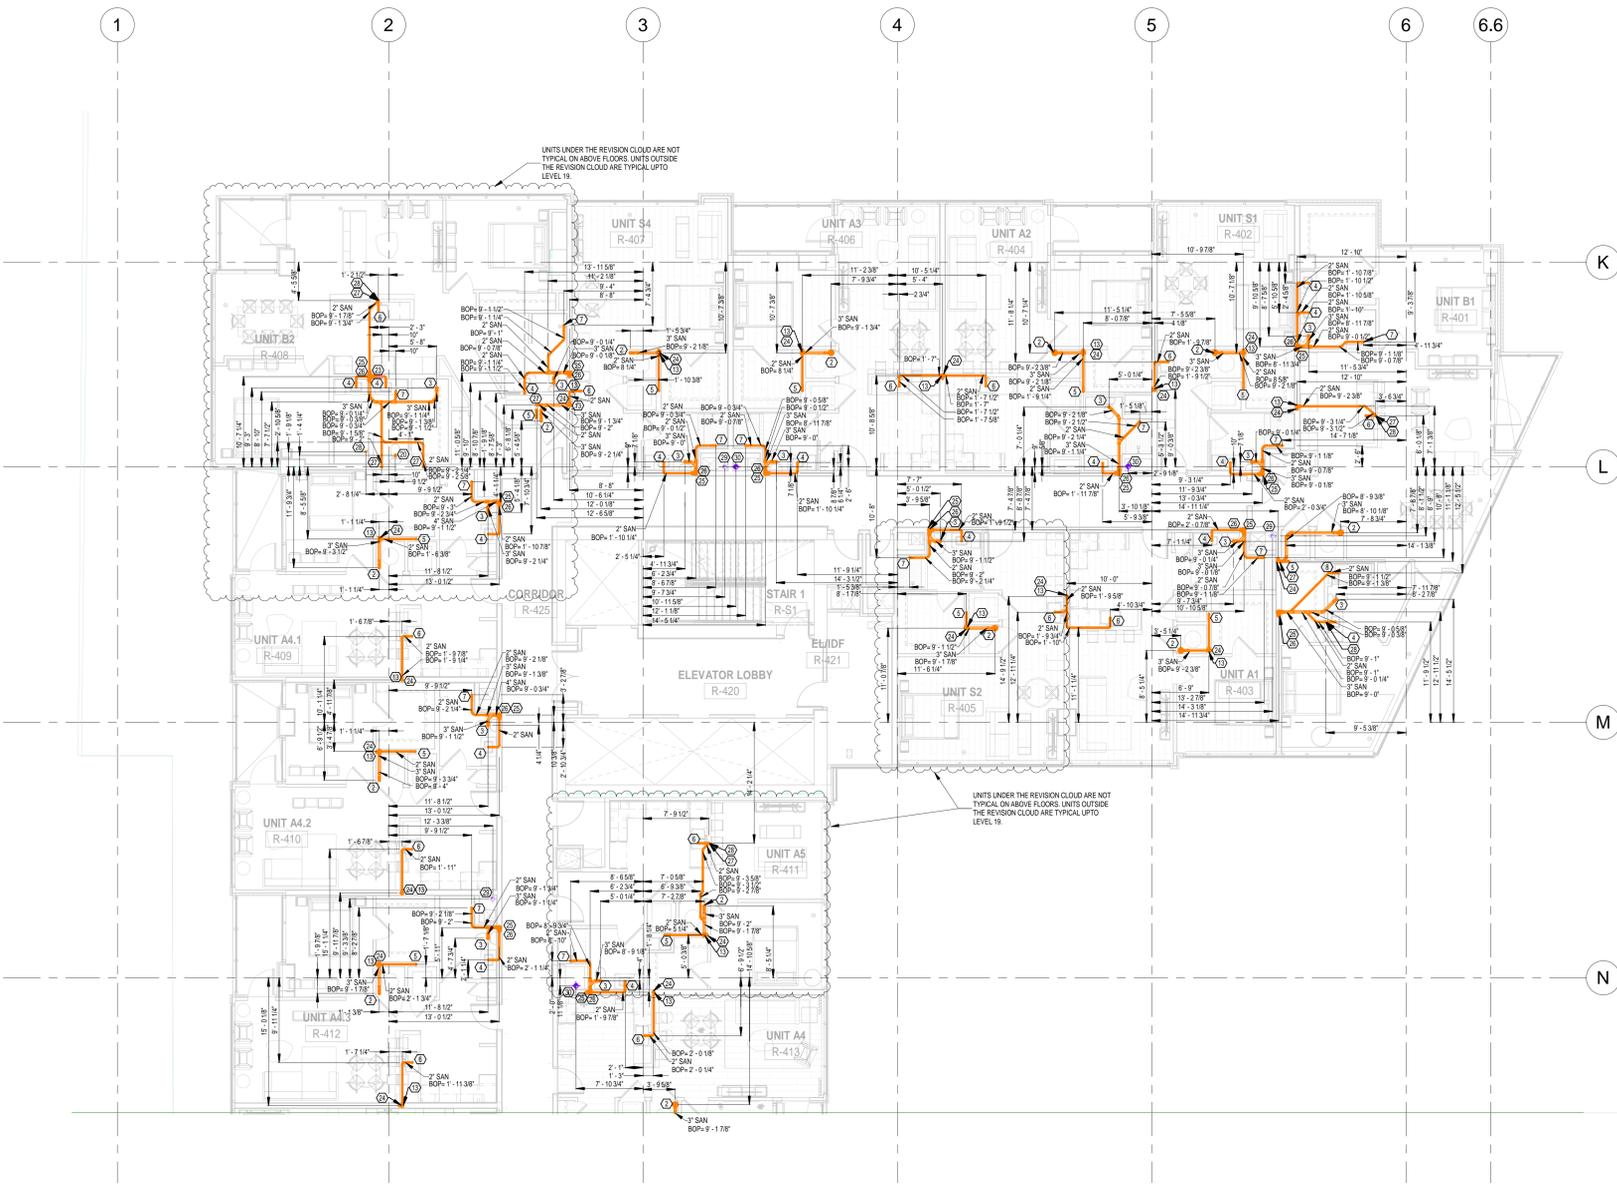

1 PLUMBING SANITARY LEVEL 4 - ZONE R1
R-P228 1/8" = 1'-0"

GENERAL NOTES

- ALL ELEVATIONS ARE MEASURED FROM LEVEL -04@1121' 8".
- ALL DIMENSIONS & ELEVATIONS ARE IN FEET AND INCHES.
- COORDINATION PROCESS IS STILL UNDER PROGRESS. PLEASE DO NOT CONSIDER THIS DRAWING AS FINAL ONE.

ABBREVIATION


SD	STORM DRAIN
PR	PROMENADE DRAIN
SAN	SANITARY
V	VENT
BOP	BOTTOM OF PIPE
FD	FLOOR DRAIN
OSD	OVERFLOW STORM DRAIN
PRL	PRESSURE RELIEF LINE
HD	HUB DRAIN

KEY NOTES

①	6" SAN T/B
②	3" SAN FROM HD
③	3" SAN FROM WC
④	2" SAN FROM LAV
⑤	2" SAN FROM WASHING MACHINE
⑥	2" SAN FROM KITCHEN SINK
⑦	2" SAN FROM SHOWER
⑧	2" SAN FROM BATH TUB
⑨	3" SAN F/A
⑩	3" PRL T/A
⑪	4" SAN F/A
⑫	4" SAN T/B
⑬	3" SAN F/A & T/B
⑭	2" V UP
⑮	6" SAN F/A
⑯	6" SD F/A
⑰	6" SD T/B
⑱	6" OSD F/A
⑲	6" OSD T/B
⑳	3" SAN T/B
㉑	2" V F/B
㉒	8" SD T/B
㉓	3" PRL FROM DEAERATOR T/B
㉔	3" AERATOR
㉕	4" AERATOR
㉖	4" SAN F/A & T/B
㉗	2" SAN F/A
㉘	2" SAN T/B
㉙	6" OSD F/A & T/B
㉚	6" SD F/A & T/B

REV. DATE DESCRIPTION

0	05.22.2024	ISSUED FOR REVIEW
---	------------	-------------------

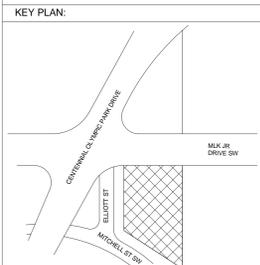

PROJECT NAME:
CENTENNIAL YARDS - HOTEL (H/E1) & RESIDENTIAL (R/E2)

AREA:
PLUMBING SANITARY LEVEL 4 - ZONE R1

SCALE	DATE
AS MENTIONED	05.22.2024

DRAWING NUMBER:
R-P228

GENERAL NOTES	
1.	ALL ELEVATIONS ARE MEASURED FROM LEVEL -09@1175' 0".
2.	ALL DIMENSIONS & ELEVATIONS ARE IN FEET AND INCHES.
3.	COORDINATION PROCESS IS STILL UNDER PROGRESS, PLEASE DO NOT CONSIDER THIS DRAWING AS FINAL ONE.


ABBREVIATION	
SD	STORM DRAIN
PR	PROMENADE DRAIN
SAN	SANITARY
V	VENT
BOP	BOTTOM OF PIPE
FD	FLOOR DRAIN
OSD	OVERFLOW STORM DRAIN
PRL	PRESSURE RELIEF LINE
HD	HUB DRAIN

KEY NOTES	
①	6" SAN T/B
②	3" SAN FROM HD
③	3" SAN FROM WC
④	2" SAN FROM LAV
⑤	2" SAN FROM WASHING MACHINE
⑥	2" SAN FROM KITCHEN SINK
⑦	2" SAN FROM SHOWER
⑧	2" SAN FROM BATH TUB
⑨	3" SAN F/A
⑩	3" PRL T/A
⑪	4" SAN F/A
⑫	4" SAN T/B
⑬	3" SAN F/A & T/B
⑭	2" V UP
⑮	6" SAN F/A
⑯	6" SD F/A
⑰	6" SD T/B
⑱	6" OSD F/A
⑲	6" OSD T/B
⑳	3" SAN T/B
㉑	2" V F/B
㉒	8" SD T/B
㉓	3" PRL FROM DEAERATOR T/B
㉔	3" AERATOR
㉕	4" AERATOR
㉖	4" SAN F/A & T/B
㉗	2" SAN F/A
㉘	2" SAN T/B
㉙	6" OSD F/A & T/B
㉚	6" SD F/A & T/B



1 PLUMBING SANITARY LEVEL 9 - ZONE R1
R-P240 1/8" = 1'-0"

REV.	DATE	DESCRIPTION
1	07.24.2024	ISSUED FOR REVIEW
0	06.04.2024	ISSUED FOR REVIEW

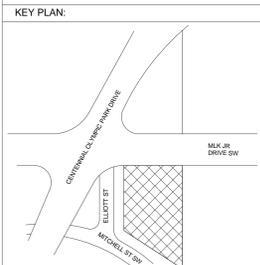

PROJECT NAME:
**CENTENNIAL YARDS -
HOTEL (H/E1) &
RESIDENTIAL (R/E2)**

AREA:
**PLUMBING SANITARY LEVEL
9 - ZONE R1**

SCALE	DATE
AS MENTIONED	07.24.2024

DRAWING NUMBER:
R-P240

GENERAL NOTES	
1.	ALL ELEVATIONS ARE MEASURED FROM LEVEL - 10@1185' 0".
2.	ALL DIMENSIONS & ELEVATIONS ARE IN FEET AND INCHES.
3.	COORDINATION PROCESS IS STILL UNDER PROGRESS. PLEASE DO NOT CONSIDER THIS DRAWING AS FINAL ONE.


ABBREVIATION	
SD	STORM DRAIN
PR	PROMENADE DRAIN
SAN	SANITARY
V	VENT
BOP	BOTTOM OF PIPE
FD	FLOOR DRAIN
T/B	TO BELOW
F/A	FROM ABOVE
HD	HUB DRAIN

KEY NOTES	
①	6" SAN T/B
②	3" SAN FROM HD
③	3" SAN FROM WC
④	2" SAN FROM LAV
⑤	2" SAN FROM WASHING MACHINE
⑥	2" SAN FROM KITCHEN SINK
⑦	2" SAN FROM SHOWER
⑧	2" SAN FROM BATH TUB
⑨	3" SAN F/A
⑩	3" PRL T/A
⑪	4" SAN F/A
⑫	4" SAN T/B
⑬	3" SAN F/A & T/B
⑭	2" V UP
⑮	6" SAN F/A
⑯	6" SD F/A
⑰	6" SD T/B
⑱	6" OSD F/A
⑲	6" OSD T/B
⑳	3" SAN T/B
㉑	2" V F/B
㉒	8" SD T/B
㉓	3" PRL FROM DEAERATOR T/B
㉔	3" AERATOR
㉕	4" AERATOR
㉖	4" SAN F/A & T/B
㉗	2" SAN F/A
㉘	2" SAN T/B
㉙	6" OSD F/A & T/B
㉚	6" SD F/A & T/B



1 PLUMBING SANITARY LEVEL 10 - ZONE R1
R-P234 1/8" = 1'-0"

REV.	DATE	DESCRIPTION
1	07.24.2024	ISSUED FOR REVIEW
0	06.04.2024	ISSUED FOR REVIEW

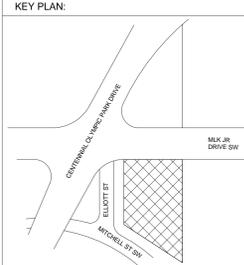

PROJECT NAME:
CENTENNIAL YARDS - HOTEL (H/E1) & RESIDENTIAL (R/E2)

AREA:
PLUMBING SANITARY LEVEL 10 - ZONE R1

SCALE	DATE
AS MENTIONED	07.24.2024

DRAWING NUMBER:

R-P234

GENERAL NOTES

- ALL ELEVATIONS ARE MEASURED FROM LEVEL - 11@1196' 4".
- ALL DIMENSIONS & ELEVATIONS ARE IN FEET AND INCHES.
- COORDINATION PROCESS IS STILL UNDER PROGRESS. PLEASE DO NOT CONSIDER THIS DRAWING AS FINAL ONE.

ABBREVIATION

SD	STORM DRAIN
PR	PROMENADE DRAIN
SAN	SANITARY
V	VENT
BOP	BOTTOM OF PIPE
FD	FLOOR DRAIN
T/B	TO BELOW
F/A	FROM ABOVE
HD	HUB DRAIN

KEY NOTES

①	6" SAN T/B
②	3" SAN FROM HD
③	3" SAN FROM WC
④	2" SAN FROM LAV
⑤	2" SAN FROM WASHING MACHINE
⑥	2" SAN FROM KITCHEN SINK
⑦	2" SAN FROM SHOWER
⑧	2" SAN FROM BATH TUB
⑨	3" SAN F/A
⑩	3" PRL T/A
⑪	4" SAN F/A
⑫	4" SAN T/B
⑬	3" SAN F/A & T/B
⑭	2" V UP
⑮	6" SAN F/A
⑯	6" SD F/A
⑰	6" SD T/B
⑱	6" OSD F/A
⑲	6" OSD T/B
⑳	3" SAN T/B
㉑	2" V F/B
㉒	8" SD T/B
㉓	3" PRL FROM DEAERATOR T/B
㉔	3" AERATOR
㉕	4" AERATOR
㉖	4" SAN F/A & T/B
㉗	2" SAN F/A
㉘	2" SAN T/B
㉙	6" OSD F/A & T/B
㉚	6" SD F/A & T/B



1 PLUMBING SANITARY LEVEL 11 - ZONE R1
R-P238 1/8" = 1'-0"

REV. DATE DESCRIPTION

1	07.24.2024	ISSUED FOR REVIEW
0	06.04.2024	ISSUED FOR REVIEW



PROJECT NAME:
CENTENNIAL YARDS - HOTEL (H/E1) & RESIDENTIAL (R/E2)

AREA:
PLUMBING SANITARY LEVEL 11 - ZONE R1

SCALE	DATE
AS MENTIONED	07.24.2024


DRAWING NUMBER:

R-P238

GENERAL NOTES	
1.	ALL ELEVATIONS ARE MEASURED FROM LEVEL- 12@1207' 0".
2.	ALL DIMENSIONS & ELEVATIONS ARE IN FEET AND INCHES.
3.	COORDINATION PROCESS IS STILL UNDER PROGRESS. PLEASE DO NOT CONSIDER THIS DRAWING AS FINAL ONE.

ABBREVIATION	
SD	STORM DRAIN
PR	PROMENADE DRAIN
SAN	SANITARY
V	VENT
BOP	BOTTOM OF PIPE
FD	FLOOR DRAIN
T/B	TO BELOW
F/A	FROM ABOVE
HD	HUB DRAIN

KEY NOTES	
①	6" SAN T/B
②	3" SAN FROM HD
③	3" SAN FROM WC
④	2" SAN FROM LAV
⑤	2" SAN FROM WASHING MACHINE
⑥	2" SAN FROM KITCHEN SINK
⑦	2" SAN FROM SHOWER
⑧	2" SAN FROM BATH TUB
⑨	3" SAN F/A
⑩	3" PRL T/A
⑪	4" SAN F/A
⑫	4" SAN T/B
⑬	3" SAN F/A & T/B
⑭	2" V UP
⑮	6" SAN F/A
⑯	6" SD F/A
⑰	6" SD T/B
⑱	6" OSD F/A
⑲	6" OSD T/B
⑳	3" SAN T/B
㉑	2" V F/B
㉒	8" SD T/B
㉓	3" PRL FROM DEAERATOR T/B
㉔	3" AERATOR
㉕	4" AERATOR
㉖	4" SAN F/A & T/B
㉗	2" SAN F/A
㉘	2" SAN T/B
㉙	6" OSD F/A & T/B
㉚	6" SD F/A & T/B

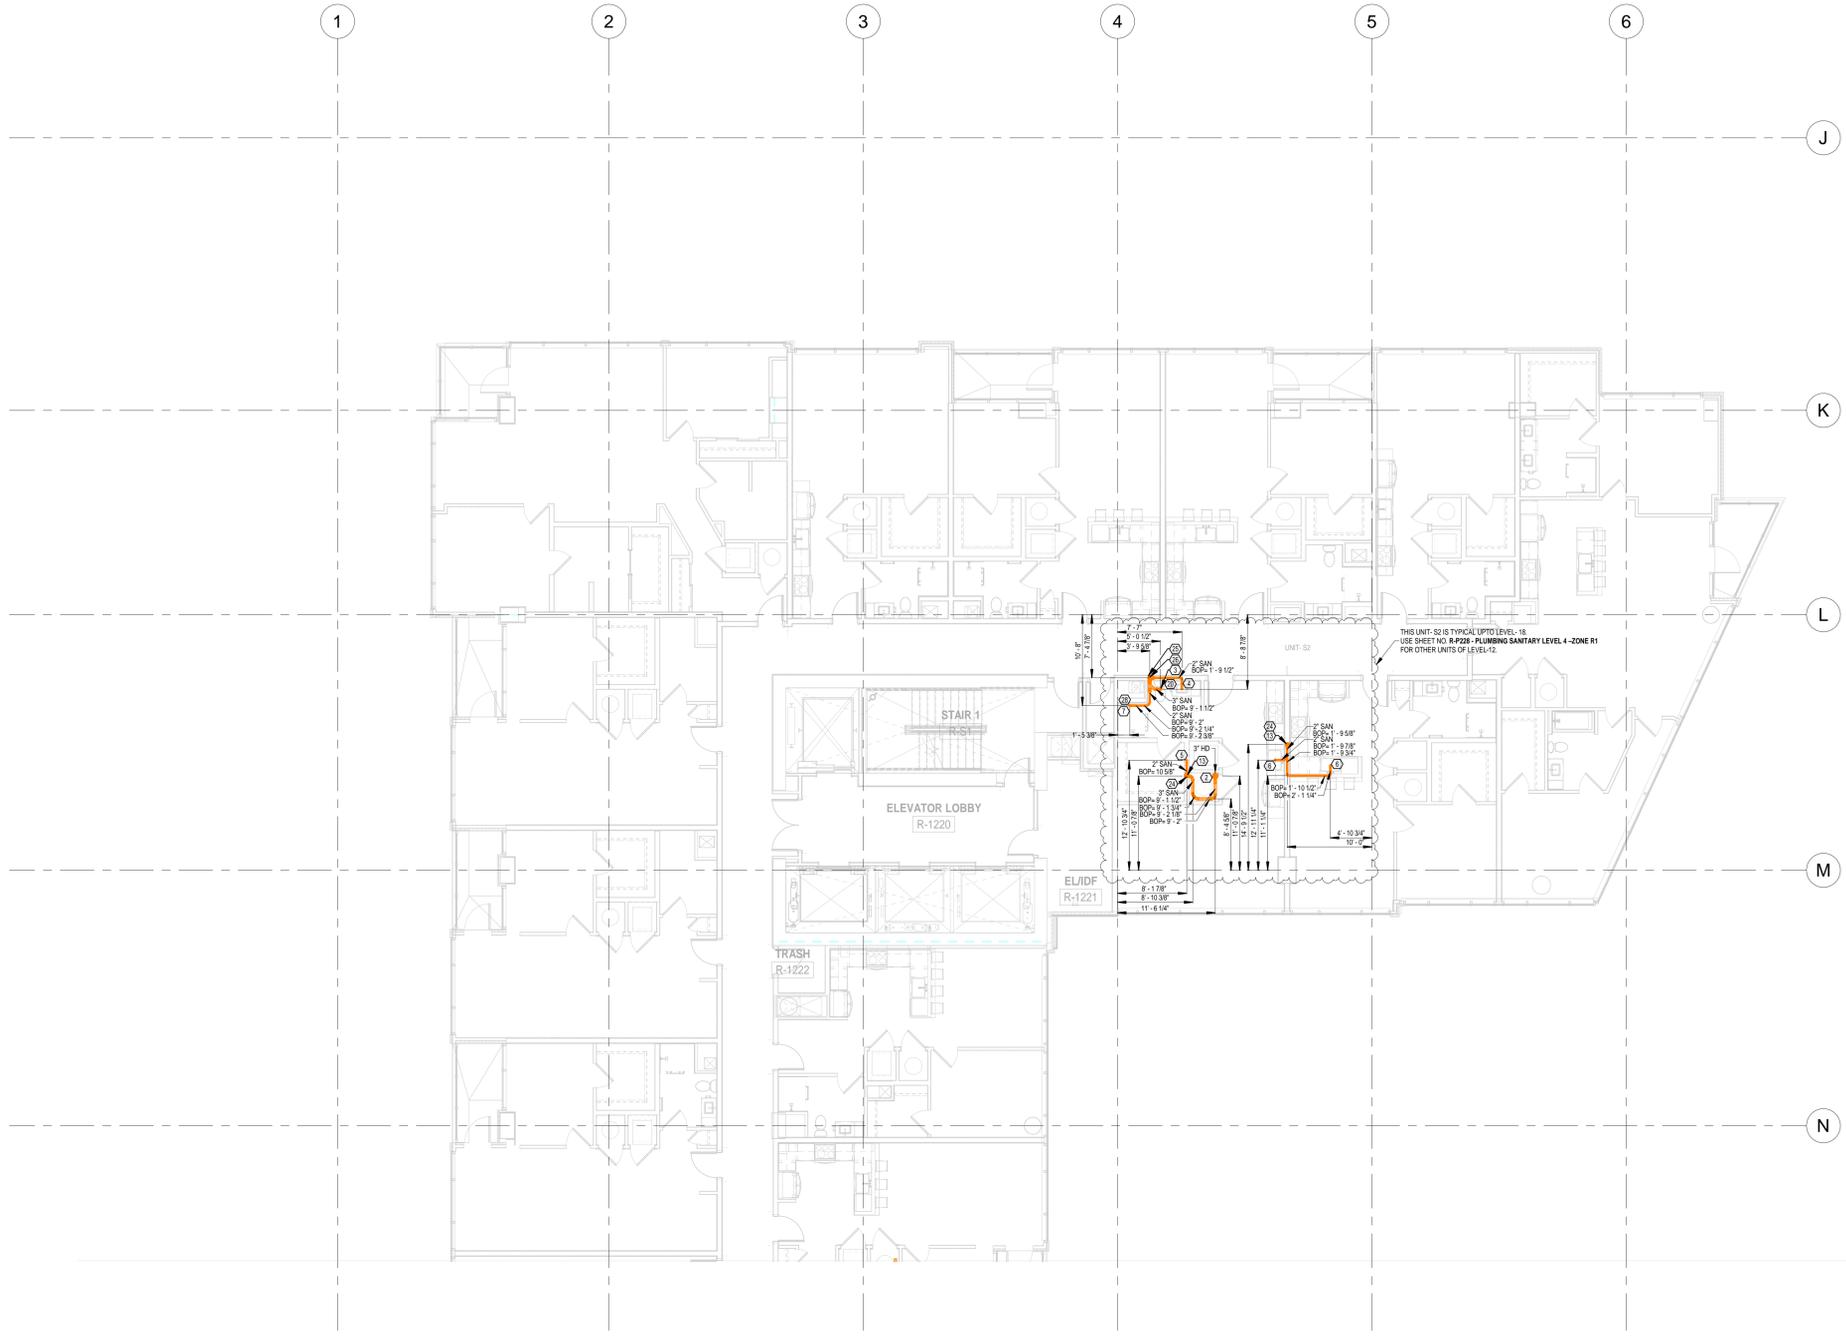

1 PLUMBING SANITARY LEVEL 12 - ZONE R1
R-P239 1/8" = 1'-0"

REV.	DATE	DESCRIPTION
1	07.24.2024	ISSUED FOR REVIEW
0	06.04.2024	ISSUED FOR REVIEW



PROJECT NAME:
CENTENNIAL YARDS - HOTEL (H/E1) & RESIDENTIAL (R/E2)

AREA:
PLUMBING SANITARY LEVEL 12 - ZONE R1

SCALE	DATE
AS MENTIONED	07.24.2024

DRAWING NUMBER:
R-P239

GENERAL NOTES


1. ALL ELEVATIONS ARE MEASURED FROM LEVEL -14@1217' 6".
2. ALL DIMENSIONS & ELEVATIONS ARE IN FEET AND INCHES.
3. COORDINATION PROCESS IS STILL UNDER PROGRESS. PLEASE DO NOT CONSIDER THIS DRAWING AS FINAL ONE.

ABBREVIATION

SD	STORM DRAIN
PR	PROMENADE DRAIN
SAN	SANITARY
V	VENT
BOP	BOTTOM OF PIPE
FD	FLOOR DRAIN
OSD	OVERFLOW STORM DRAIN
PRL	PRESSURE RELIEF LINE
HD	HUB DRAIN

KEY NOTES


①	6" SAN T/B
②	3" SAN FROM HD
③	3" SAN FROM WC
④	2" SAN FROM LAV
⑤	2" SAN FROM WASHING MACHINE
⑥	2" SAN FROM KITCHEN SINK
⑦	2" SAN FROM SHOWER
⑧	2" SAN FROM BATH TUB
⑨	3" SAN F/A
⑩	3" PRL T/A
⑪	4" SAN F/A
⑫	4" SAN T/B
⑬	3" SAN F/A & T/B
⑭	2" V UP
⑮	6" SAN F/A
⑯	6" SD F/A
⑰	6" SD T/B
⑱	6" OSD F/A
⑲	6" OSD T/B
⑳	3" SAN T/B
㉑	2" V F/B
㉒	8" SD T/B
㉓	3" PRL FROM DEAERATOR T/B
㉔	3" AERATOR
㉕	4" AERATOR
㉖	4" SAN F/A & T/B
㉗	2" SAN F/A
㉘	2" SAN T/B
㉙	6" OSD F/A & T/B
㉚	6" SD F/A & T/B

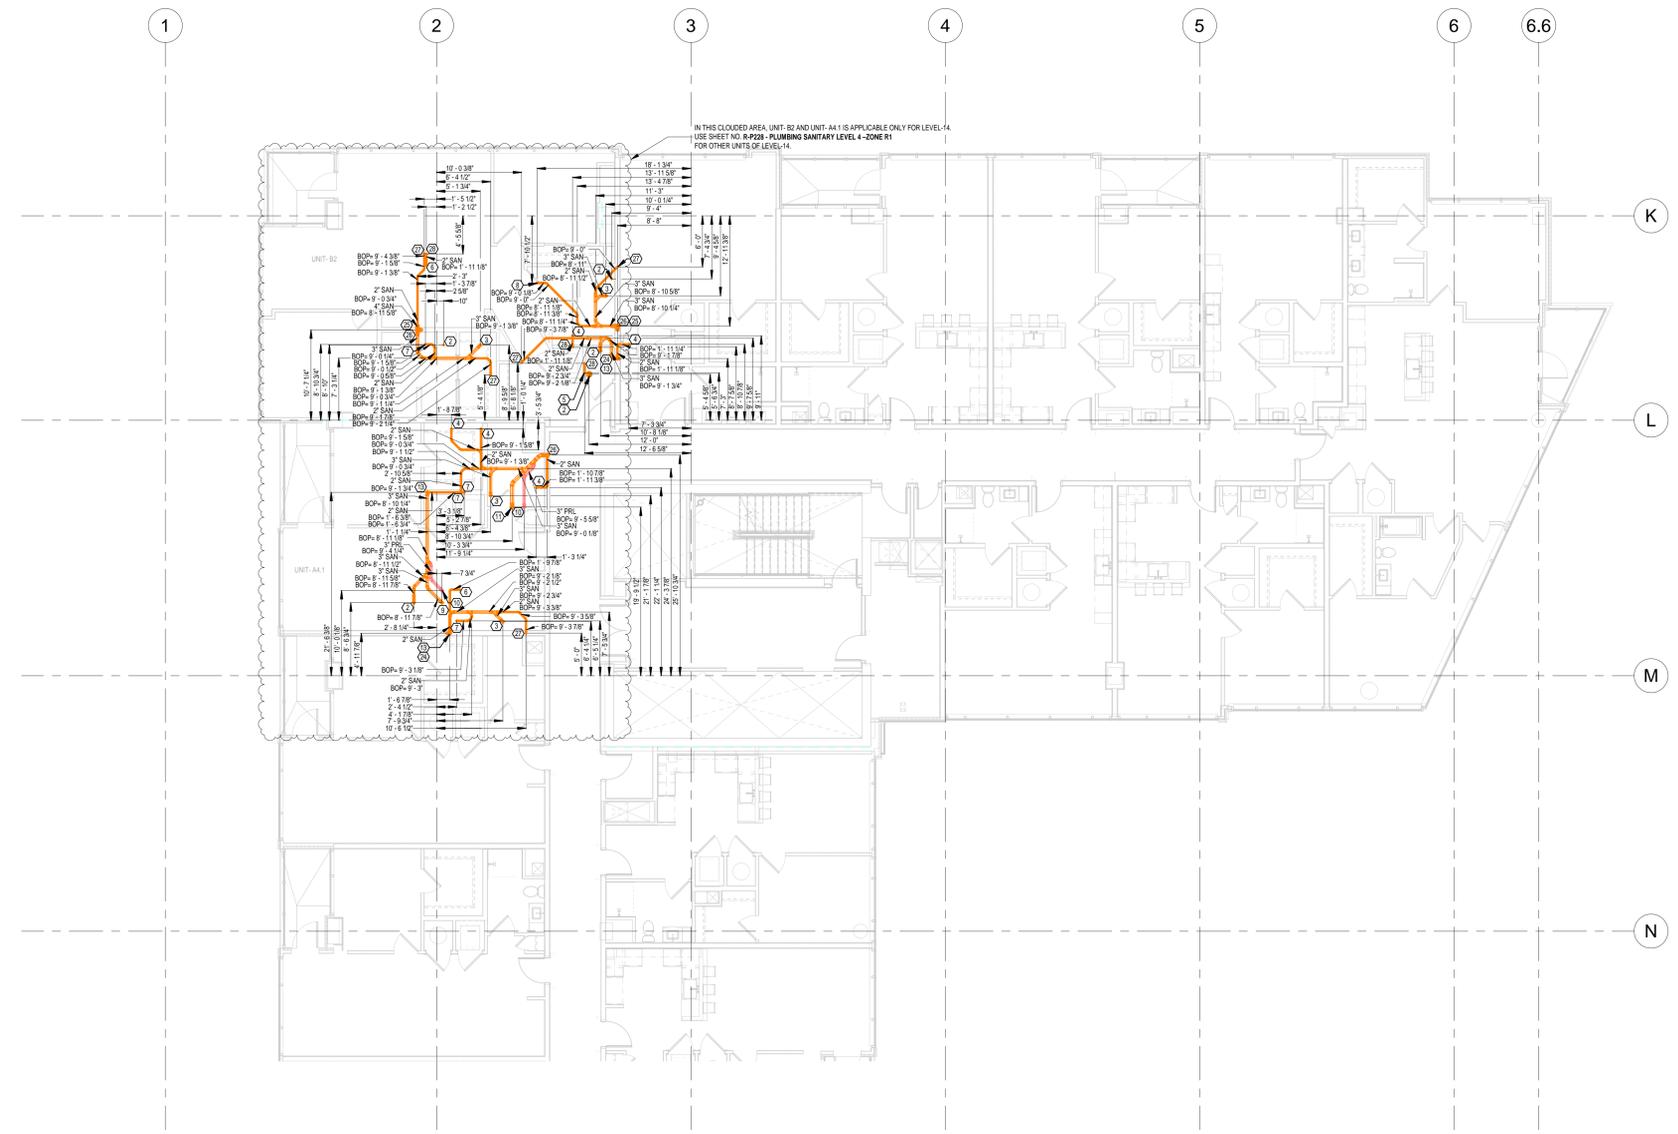

1 PLUMBING SANITARY LEVEL 14 - ZONE R1
R-P241 1/8" = 1'-0"

REV. DATE DESCRIPTION

1	07.24.2024	ISSUED FOR REVIEW
0	06.04.2024	ISSUED FOR REVIEW

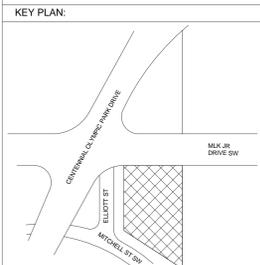

PROJECT NAME:
CENTENNIAL YARDS - HOTEL (H/E1) & RESIDENTIAL (R/E2)

AREA:
PLUMBING SANITARY LEVEL 14 - ZONE R1

SCALE	DATE
AS MENTIONED	07.24.2024

DRAWING NUMBER:
R-P241

GENERAL NOTES


1. ALL ELEVATIONS ARE MEASURED FROM LEVEL-15@1228' 4".
2. ALL DIMENSIONS & ELEVATIONS ARE IN FEET AND INCHES.
3. COORDINATION PROCESS IS STILL UNDER PROGRESS. PLEASE DO NOT CONSIDER THIS DRAWING AS FINAL ONE.

ABBREVIATION

SD	STORM DRAIN
PR	PROMENADE DRAIN
SAN	SANITARY
V	VENT
BOP	BOTTOM OF PIPE
FD	FLOOR DRAIN
OSD	OVERFLOW STORM DRAIN
PRL	PRESSURE RELIEF LINE
HD	HUB DRAIN


KEY NOTES

①	6" SAN T/B
②	3" SAN FROM HD
③	3" SAN FROM WC
④	2" SAN FROM LAV
⑤	2" SAN FROM WASHING MACHINE
⑥	2" SAN FROM KITCHEN SINK
⑦	2" SAN FROM SHOWER
⑧	2" SAN FROM BATH TUB
⑨	3" SAN F/A
⑩	3" PRL T/A
⑪	4" SAN F/A
⑫	4" SAN T/B
⑬	3" SAN F/A & T/B
⑭	2" V UP
⑮	6" SAN F/A
⑯	6" SD F/A
⑰	6" SD T/B
⑱	6" OSD F/A
⑲	6" OSD T/B
⑳	3" SAN T/B
㉑	2" V F/B
㉒	8" SD T/B
㉓	3" PRL FROM DEAEATOR T/B
㉔	3" AERATOR
㉕	4" AERATOR
㉖	4" SAN F/A & T/B
㉗	2" SAN F/A
㉘	2" SAN T/B
㉙	6" OSD F/A & T/B
㉚	6" SD F/A & T/B

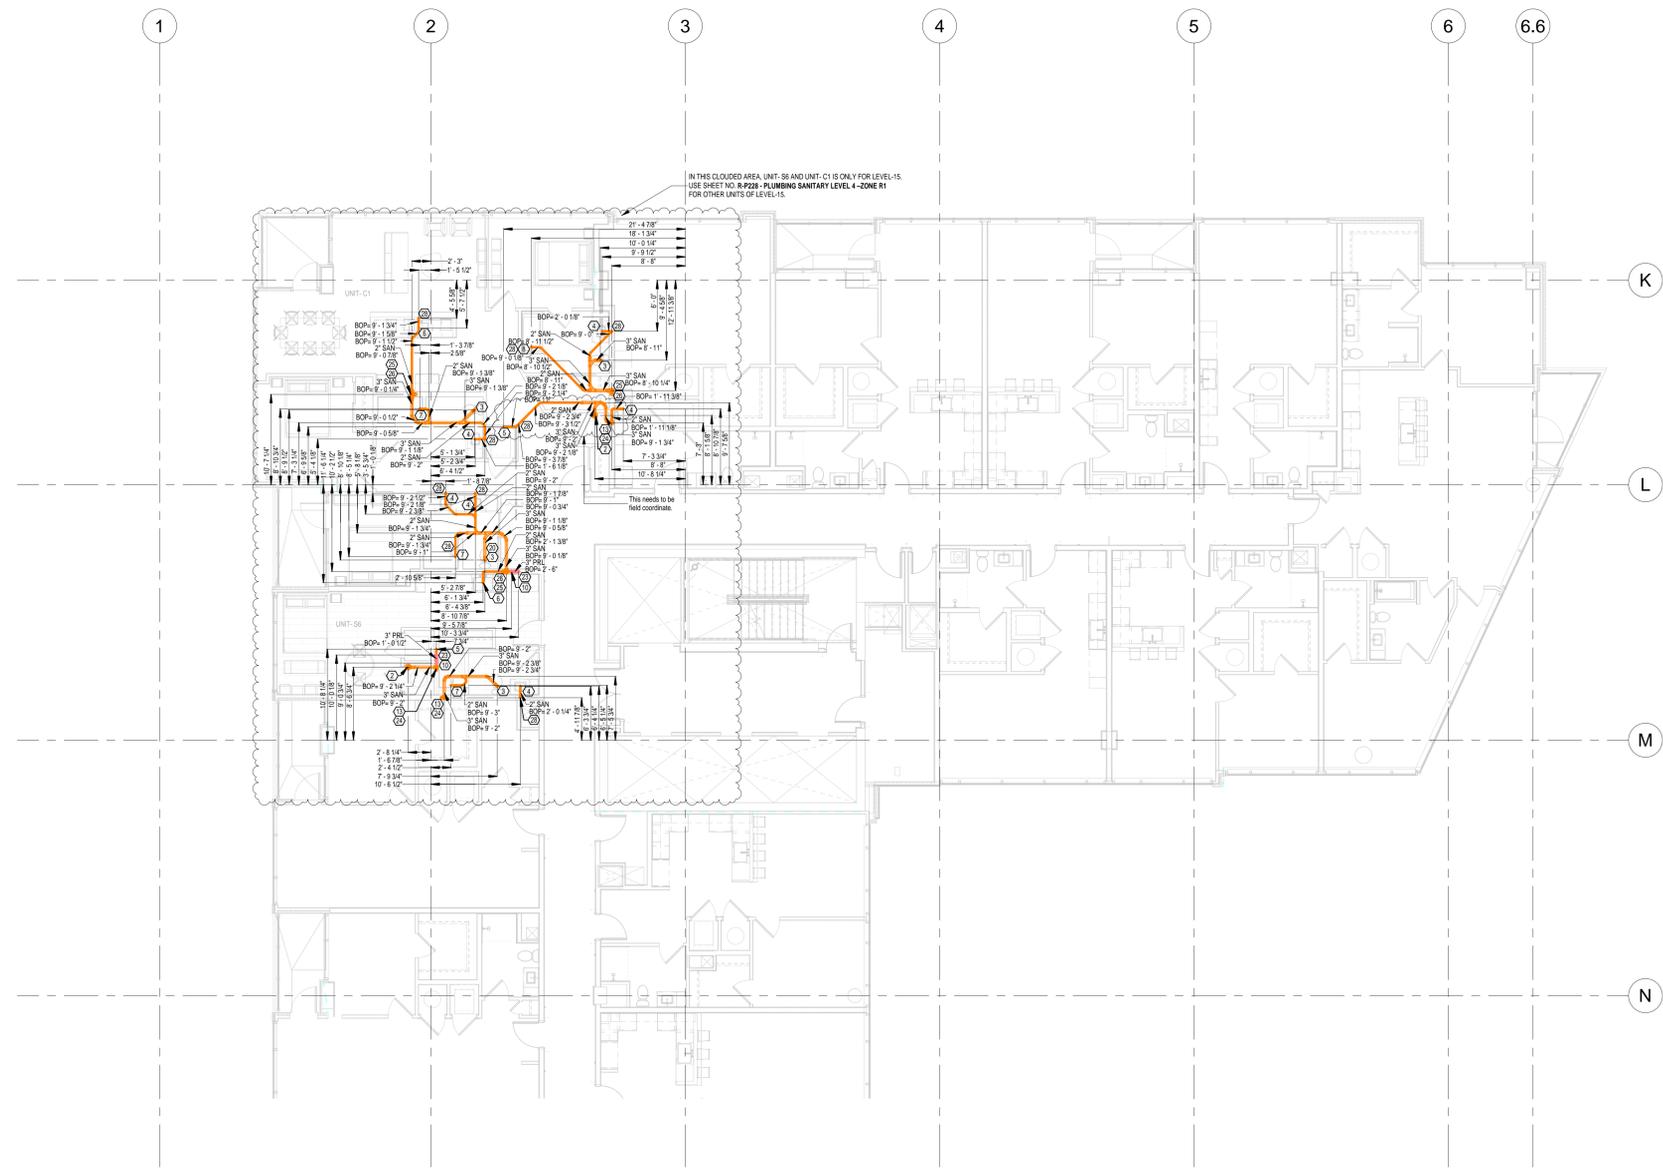

1 PLUMBING SANITARY LEVEL 15 - ZONE R1
R-P242 1/8" = 1'-0"

REV.	DATE	DESCRIPTION
1	07.24.2024	ISSUED FOR REVIEW
0	06.04.2024	ISSUED FOR REVIEW

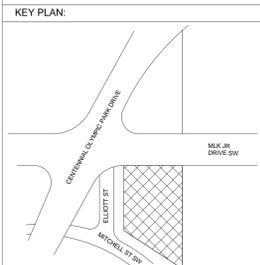

PROJECT NAME:
CENTENNIAL YARDS - HOTEL (H/E1) & RESIDENTIAL (R/E2)

AREA:
PLUMBING SANITARY LEVEL 15 - ZONE R1

SCALE	DATE
AS MENTIONED	07.24.2024

DRAWING NUMBER:
R-P242

GENERAL NOTES


- ALL ELEVATIONS ARE MEASURED FROM LEVEL- 16 @ 1239' 0".
- ALL DIMENSIONS & ELEVATIONS ARE IN FEET AND INCHES.
- COORDINATION PROCESS IS STILL UNDER PROGRESS. PLEASE DO NOT CONSIDER THIS DRAWING AS FINAL ONE.

ABBREVIATION

SD	STORM DRAIN
PR	PROMENADE DRAIN
SAN	SANITARY
V	VENT
BOP	BOTTOM OF PIPE
FD	FLOOR DRAIN
T/B	TO BELOW
F/A	FROM ABOVE
HD	HUB DRAIN

KEY NOTES


①	6" SAN T/B
②	3" SAN FROM HD
③	3" SAN FROM WC
④	2" SAN FROM LAV
⑤	2" SAN FROM WASHING MACHINE
⑥	2" SAN FROM KITCHEN SINK
⑦	2" SAN FROM SHOWER
⑧	2" SAN FROM BATH TUB
⑨	3" SAN F/A
⑩	3" PRL T/A
⑪	4" SAN F/A
⑫	4" SAN T/B
⑬	3" SAN F/A & T/B
⑭	2" V UP
⑮	6" SAN F/A
⑯	6" SD F/A
⑰	6" SD T/B
⑱	6" OSD F/A
⑲	6" OSD T/B
⑳	3" SAN T/B
㉑	2" V F/B
㉒	8" SD T/B
㉓	3" PRL FROM DEAERATOR T/B
㉔	3" AERATOR
㉕	4" AERATOR
㉖	4" SAN F/A & T/B
㉗	2" SAN F/A
㉘	2" SAN T/B
㉙	6" OSD F/A & T/B
㉚	6" SD F/A & T/B

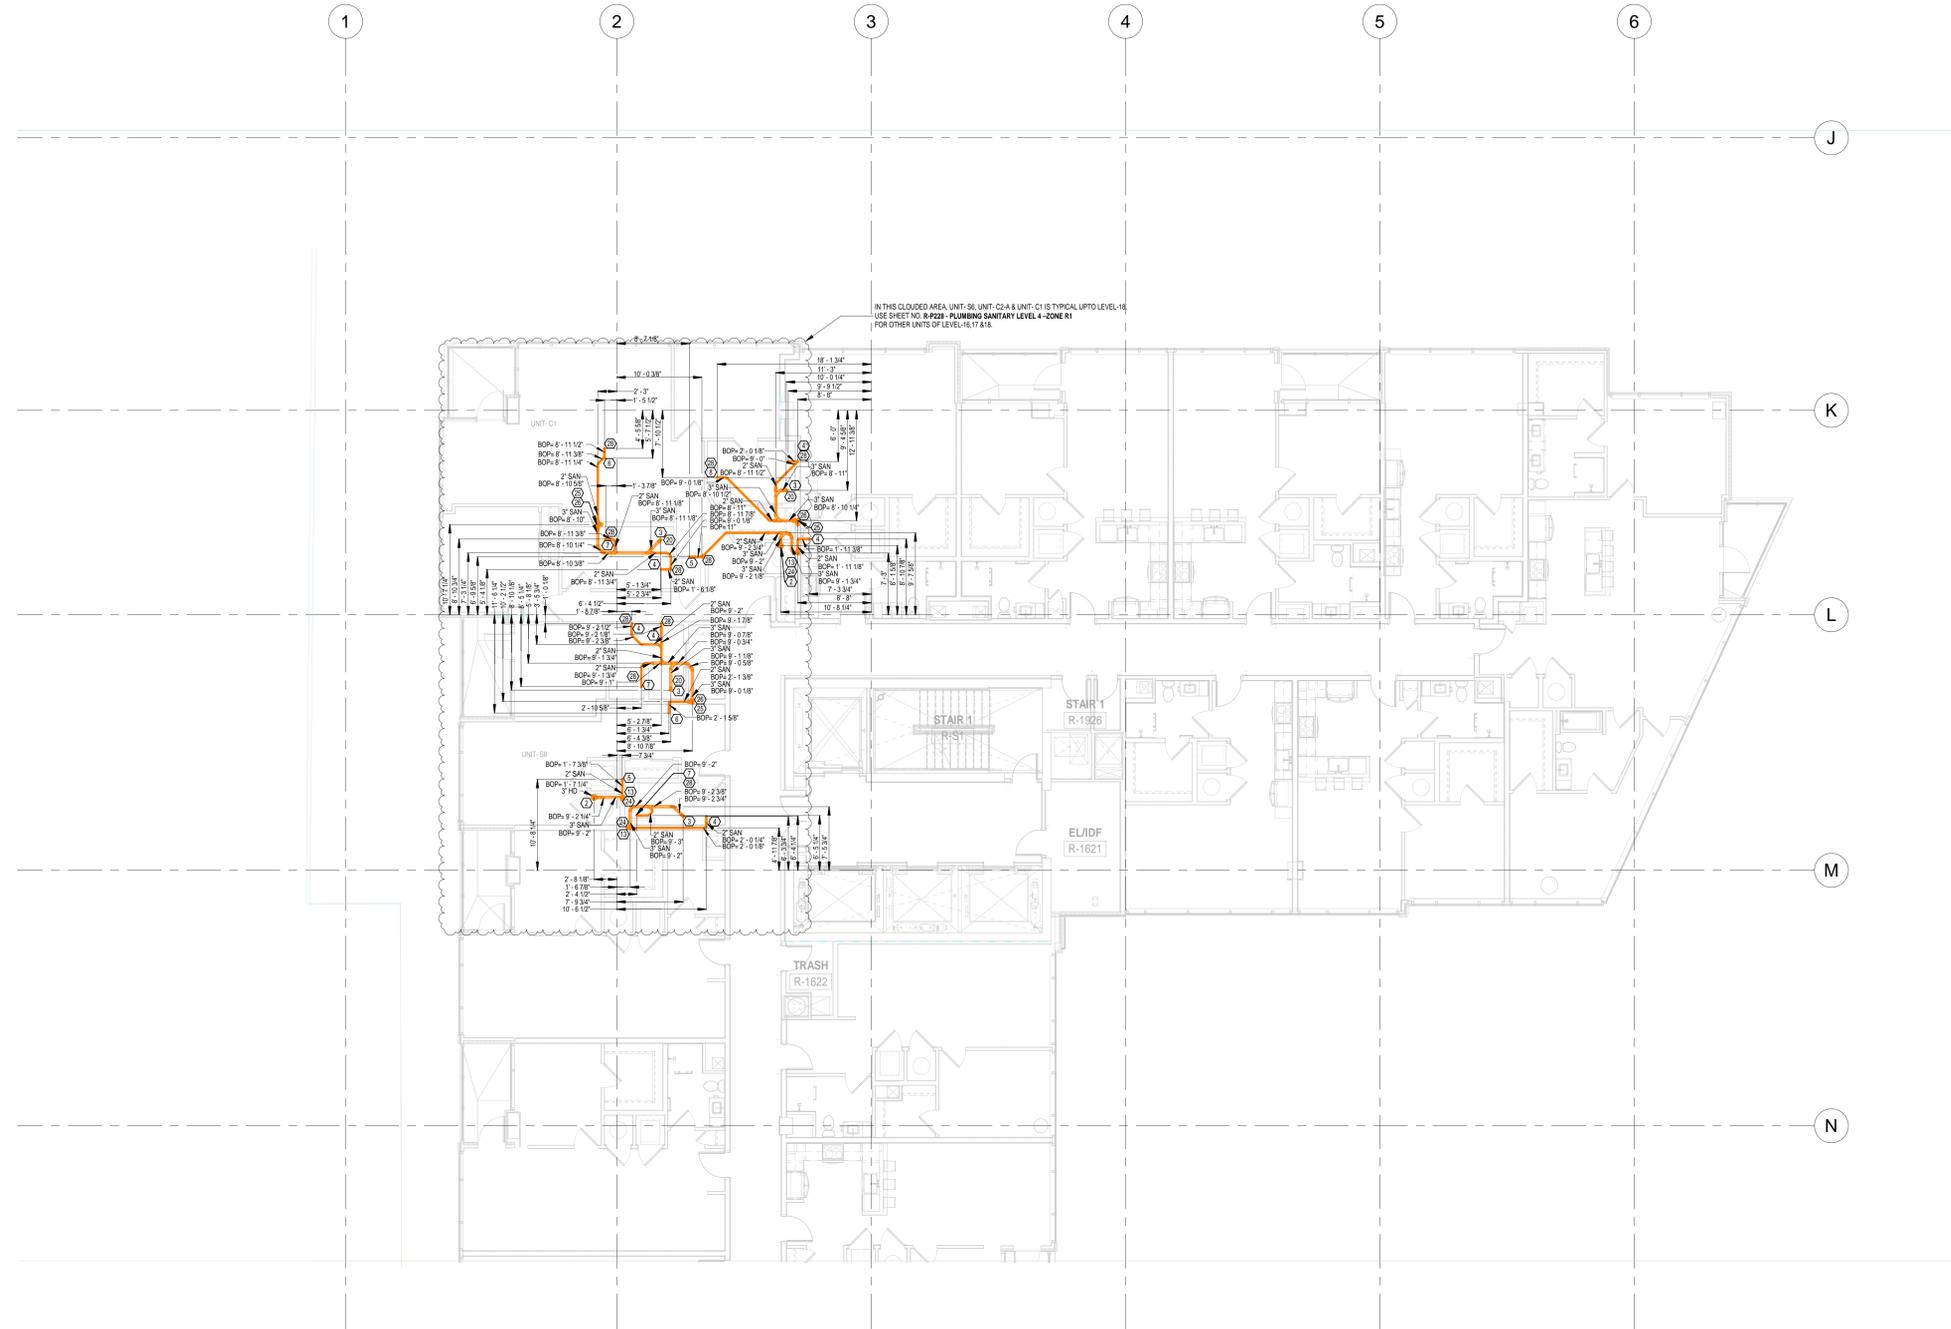

1 PLUMBING SANITARY LEVEL 16 - ZONE R1
R-P243 1/8" = 1'-0"

REV. DATE DESCRIPTION

1	07.24.2024	ISSUED FOR REVIEW
0	06.04.2024	ISSUED FOR REVIEW

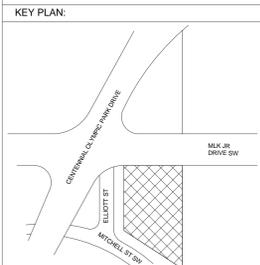

PROJECT NAME:
CENTENNIAL YARDS - HOTEL (H/E1) & RESIDENTIAL (R/E2)

AREA:
PLUMBING SANITARY LEVEL 16 - ZONE R1

SCALE	DATE
AS MENTIONED	07.24.2024


DRAWING NUMBER:
R-P243

GENERAL NOTES	
1.	ALL ELEVATIONS ARE MEASURED FROM LEVEL -19@127' 0".
2.	ALL DIMENSIONS & ELEVATIONS ARE IN FEET AND INCHES.
3.	COORDINATION PROCESS IS STILL UNDER PROGRESS. PLEASE DO NOT CONSIDER THIS DRAWING AS FINAL ONE.

ABBREVIATION	
SD	STORM DRAIN
PR	PROMENADE DRAIN
SAN	SANITARY
V	VENT
BOP	BOTTOM OF PIPE
FD	FLOOR DRAIN
F/A	FROM ABOVE
T/B	TO BELOW
T/A	TO ABOVE
DN	DOWN
OSD	OVERFLOW STORM DRAIN
PRL	PRESSURE RELIEF LINE
HD	HUB DRAIN

KEY NOTES	
①	6" SAN T/B
②	3" SAN FROM HD
③	3" SAN FROM WC
④	2" SAN FROM LAV
⑤	2" SAN FROM WASHING MACHINE
⑥	2" SAN FROM KITCHEN SINK
⑦	2" SAN FROM SHOWER
⑧	2" SAN FROM BATH TUB
⑨	3" SAN F/A
⑩	3" PRL T/A
⑪	4" SAN F/A
⑫	4" SAN T/B
⑬	3" SAN F/A & T/B
⑭	2" V UP
⑮	6" SAN F/A
⑯	6" SD T/B
⑰	6" OSD F/A
⑱	6" OSD T/B
⑲	3" SAN T/B
⑳	2" V FB
㉑	8" SD T/B
㉒	3" PRL FROM DEAERATOR T/B
㉓	3" AERATOR
㉔	4" AERATOR
㉕	4" SAN F/A & T/B
㉖	2" SAN F/A
㉗	2" SAN T/B
㉘	6" OSD F/A & T/B
㉙	6" SD F/A & T/B

REV.	DATE	DESCRIPTION
0	07.31.2024	ISSUED FOR REVIEW

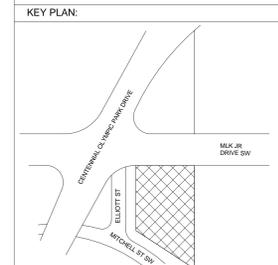


PROJECT NAME:
CENTENNIAL YARDS - HOTEL (H/E1) & RESIDENTIAL (R/E2)

AREA:
PLUMBING SANITARY LEVEL 19 - ZONE R1

SCALE: AS MENTIONED
DATE: 07.31.2024

DRAWING NUMBER:

R-P244

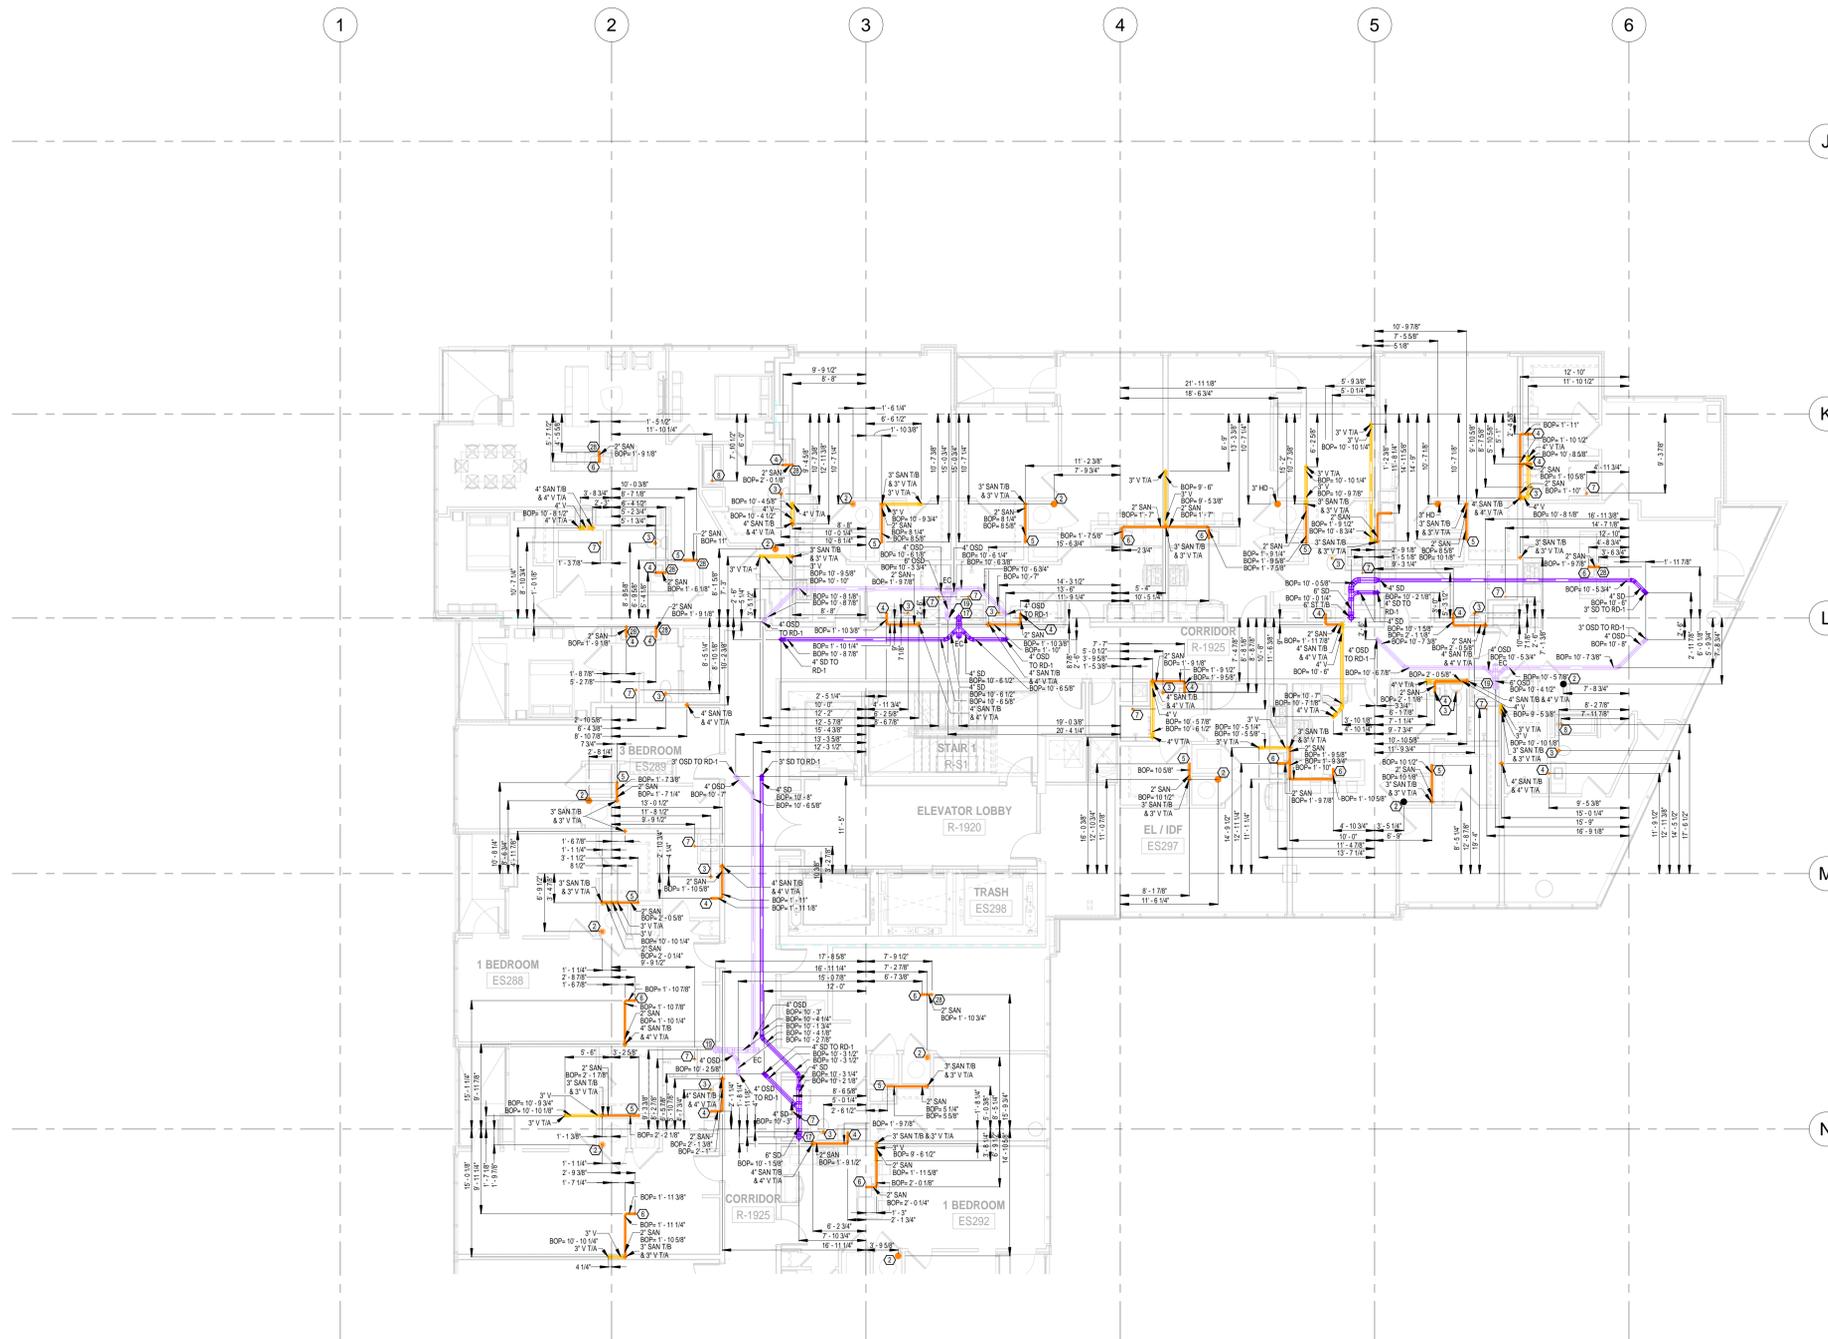

1 PLUMBING SANITARY LEVEL 19 - ZONE R1
R-P244 1/8" = 1'-0"

